


10'-0" 1/2" 25'-3" 9/8" 40'-0" 1/4"

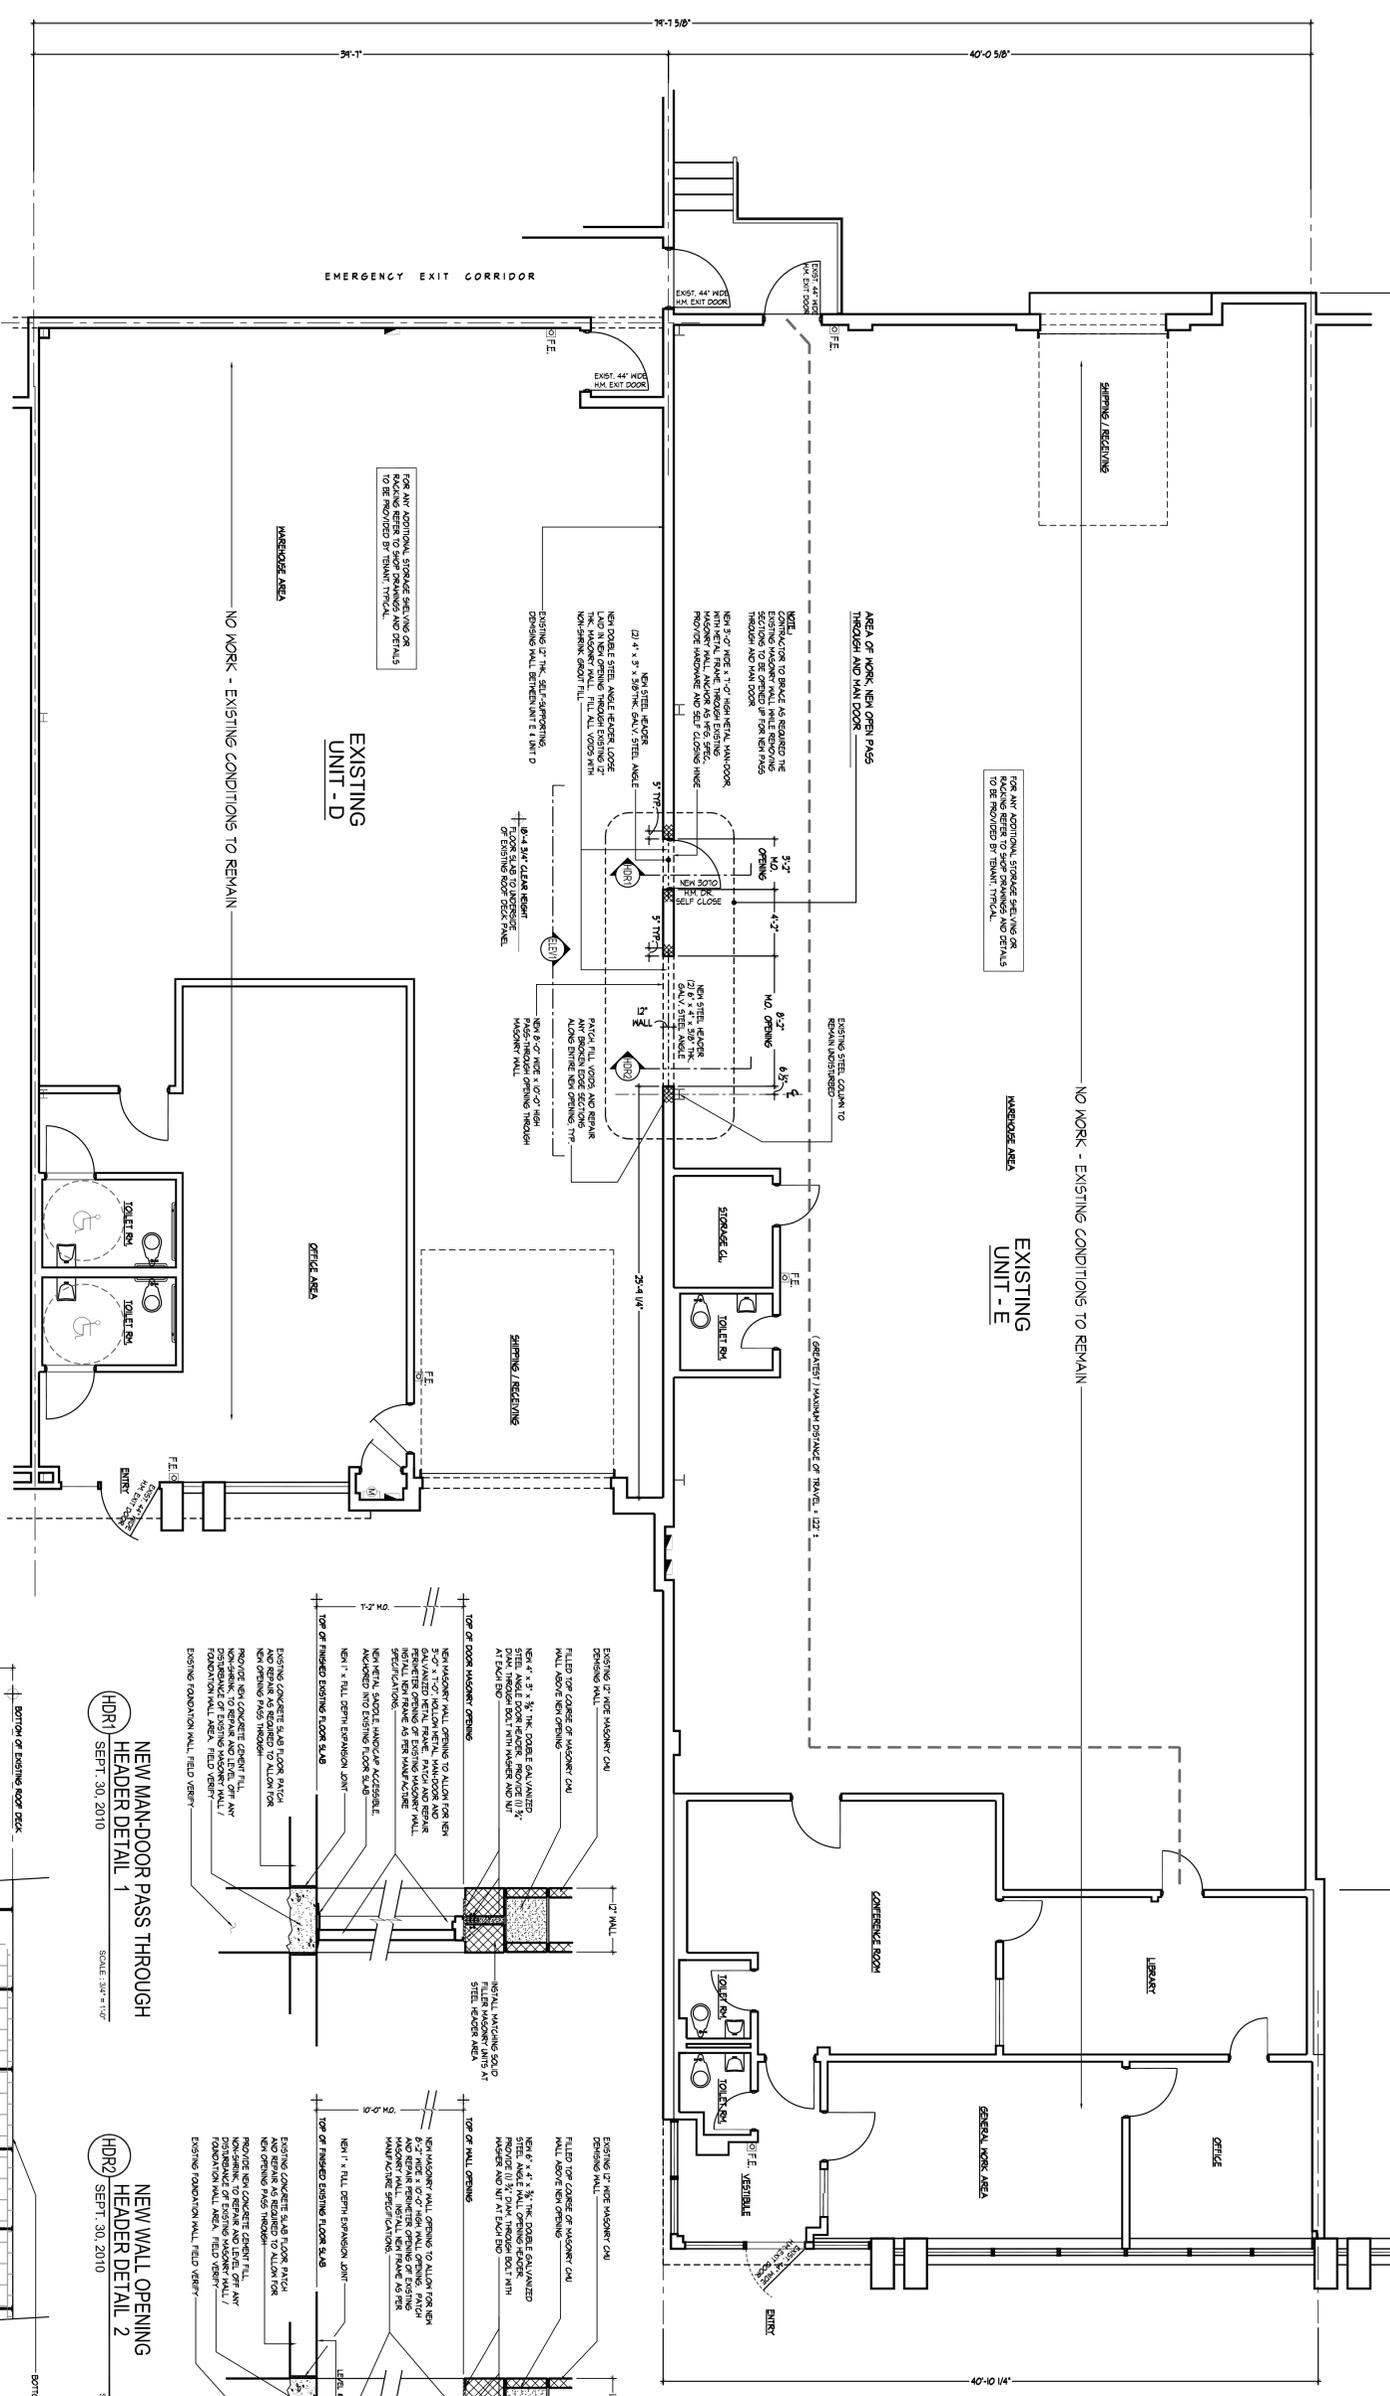

NOTE:
 PORTABLE FIRE EXTINGUISHER - TYPE ABC, LOCATED WITHIN WORK AREA FOR CABINET REPAIRS AND ACCESSORIES, 13.75" HALL SPACED SEPARATION

 
NOTE:
 THE EXISTING BUILDING FACILITY DOES NOT HAVE A FIRE ALARM SYSTEM BUT DOES HAVE A SMOKE DETECTION SYSTEM THROUGHOUT THE EXISTING DUCT WORK. THE GENERAL CONTRACTOR MUST ADAPT THE SMOKE DETECTION SYSTEM TO BE TIED INTO THE EXISTING SMOKE DETECTION SYSTEM.

THE EXISTING BUILDING DOES HAVE A FIRE SPRINKLER SYSTEM.




A


855 CONKLIN STREET - UNIT E & D
 EXISTING & PROPOSED COMBINED TENANCY FLOOR PLAN
 SEPT. 30, 2010




NOTE:
 THE BUILDING CONTAINS AN EXISTING FIRE SPRINKLER SYSTEM THROUGHOUT ALL AREAS.

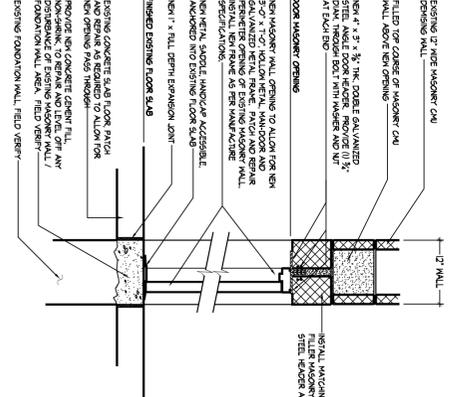

HD1 SEPT. 30, 2010
 NEW MAN-DOOR PASS THROUGH
 HEADER DETAIL 1
 SCALE: 3/4\"/>

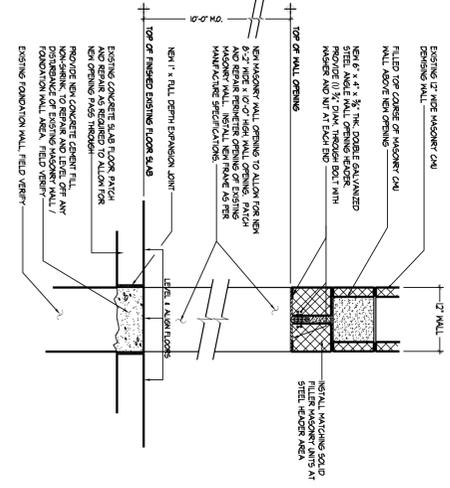

HD2 SEPT. 30, 2010
 NEW WALL OPENING
 HEADER DETAIL 2
 SCALE: 3/4\"/>

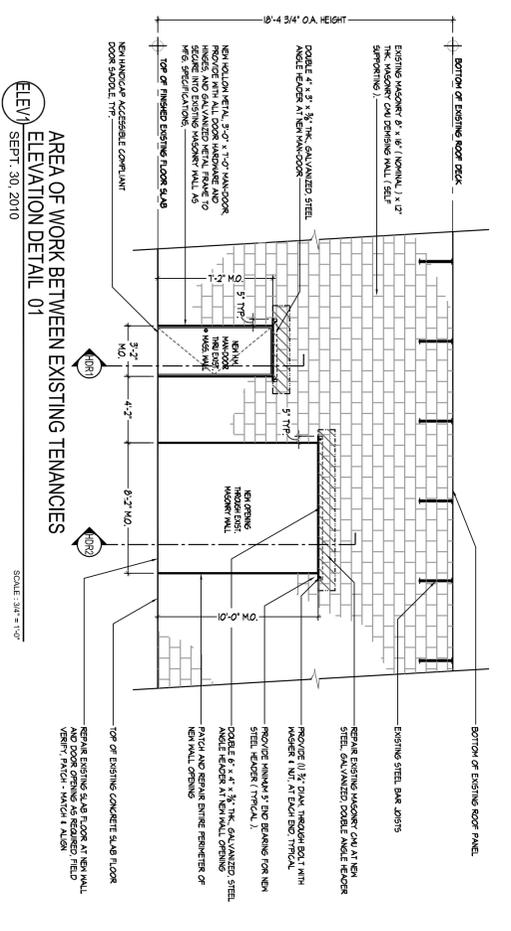

ELEV1 SEPT. 30, 2010
 AREA OF WORK BETWEEN EXISTING TENANCIES
 ELEVATION DETAIL 01
 SCALE: 3/4\"/>

| | | | | | | | |
|---|--|--|--|--|--|------------------------------------|------------|
| CONSTRUCTION FLOOR PLAN & DETAILS DATE: 09/28/2015 SCALE: AS SHOWN DRAWN BY: PDA.pc CHECKED BY: SC | | PRECISION DESIGNS ARCHITECTURE P.C. ARCHITECTURAL DESIGN & DRAFTING SERVICES 52 COMMERCE DRIVE MR. SAMUEL CICCOLELLA, R.A., A.I.A. EAST FARMINGDALE, NEW YORK 11735-1208 PHONE: 631-501-0340 FAX: 631-501-0342 EMAIL: pdone@pdarch.com | | PREPARED FOR: 855 CONKLIN STREET, UNIT - E & D INTERIOR ALTERATION - COMBINING TENANCIES UNIT - E & D, 855 CONKLIN STREET FARMINGDALE, NEW YORK 11735 TOWN OF BABYLON, SUFFOLK COUNTY SUFFOLK COUNTY TAX MAP NUMBER: DISTRICT: 100 SECTION: 046.00 BLOCK: 01.00 LOT(S): 046.00 | | REVISION: DATE: DESCRIPTION: | SIGN DATE: |
| 1.0 AR-1 | | NOTICE: THESE DRAWINGS ARE THE PROPERTY OF PRECISION DESIGNS ARCHITECTURE P.C. AND ARE TO BE USED ONLY FOR THE PROJECT AND SITE SPECIFICALLY IDENTIFIED HEREIN. ANY REUSE OR REPRODUCTION OF THESE DRAWINGS WITHOUT THE WRITTEN PERMISSION OF PRECISION DESIGNS ARCHITECTURE P.C. IS STRICTLY PROHIBITED. THE USER OF THESE DRAWINGS SHALL BE RESPONSIBLE FOR OBTAINING ALL NECESSARY PERMITS AND FOR VERIFYING ALL INFORMATION AND CONDITIONS ON THE JOB SITE. PRECISION DESIGNS ARCHITECTURE P.C. ACCEPTS NO LIABILITY FOR ANY DAMAGE OR LOSS OF ANY KIND, INCLUDING CONSEQUENTIAL DAMAGES, ARISING FROM THE USE OF THESE DRAWINGS. ALL RIGHTS RESERVED. | | | | | |