


HSBC


BRANCH BANK

551 PASSAIC AVE
WEST CALDWELL, NJ
07006

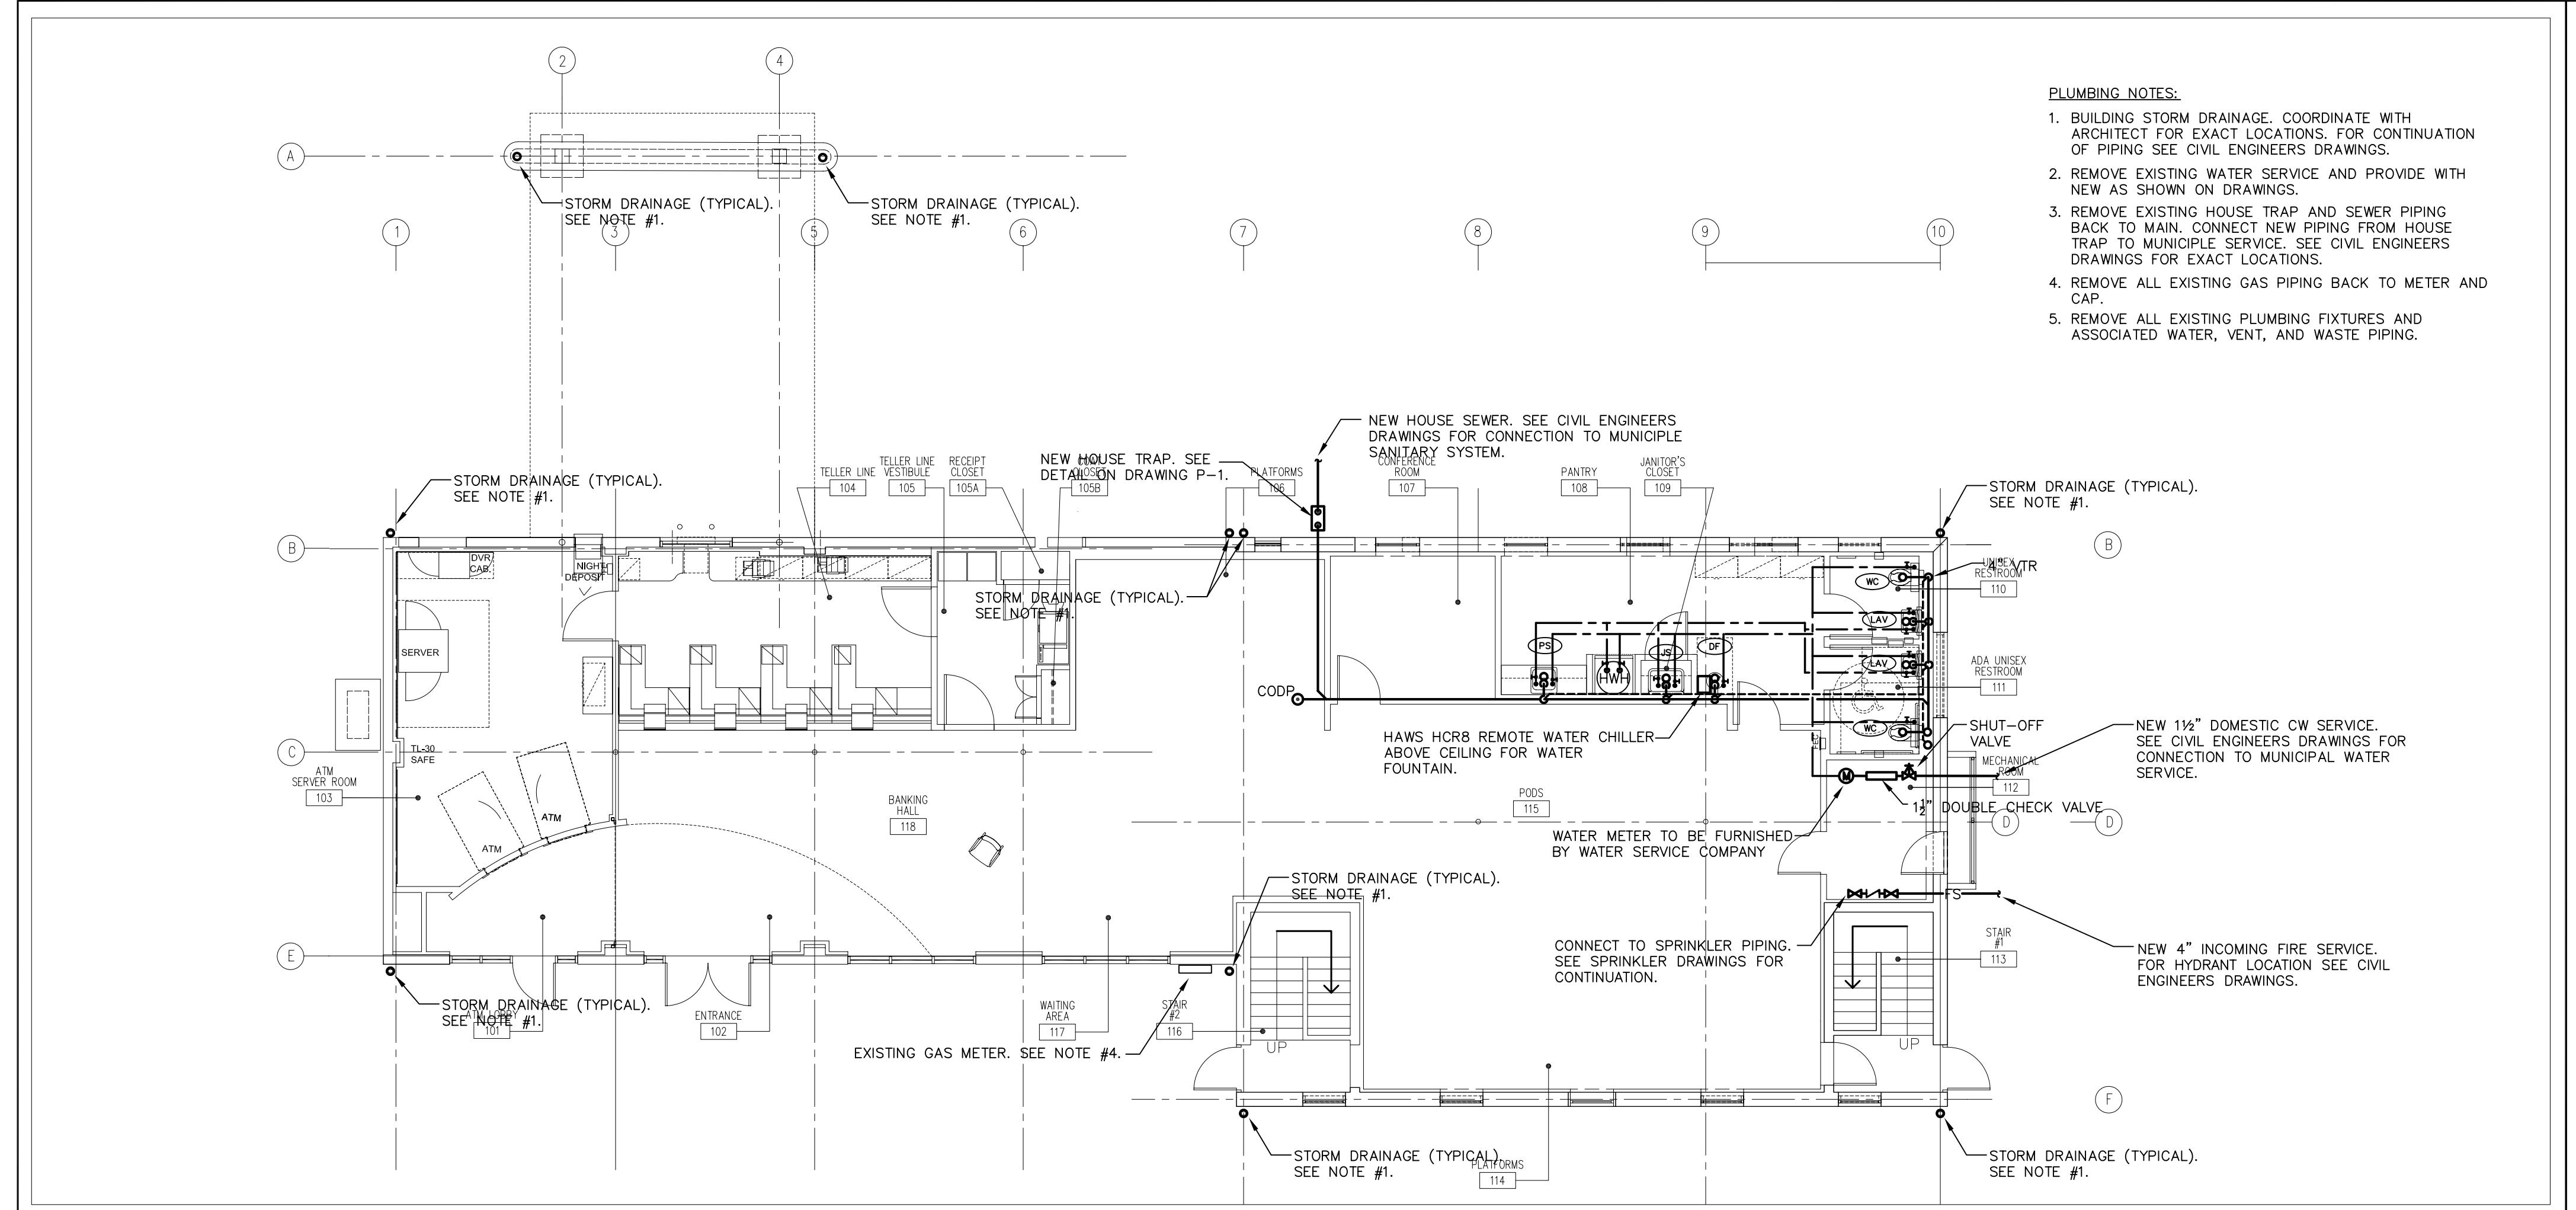

1 FIRST FLOOR PLAN

1/8"=1'-0"

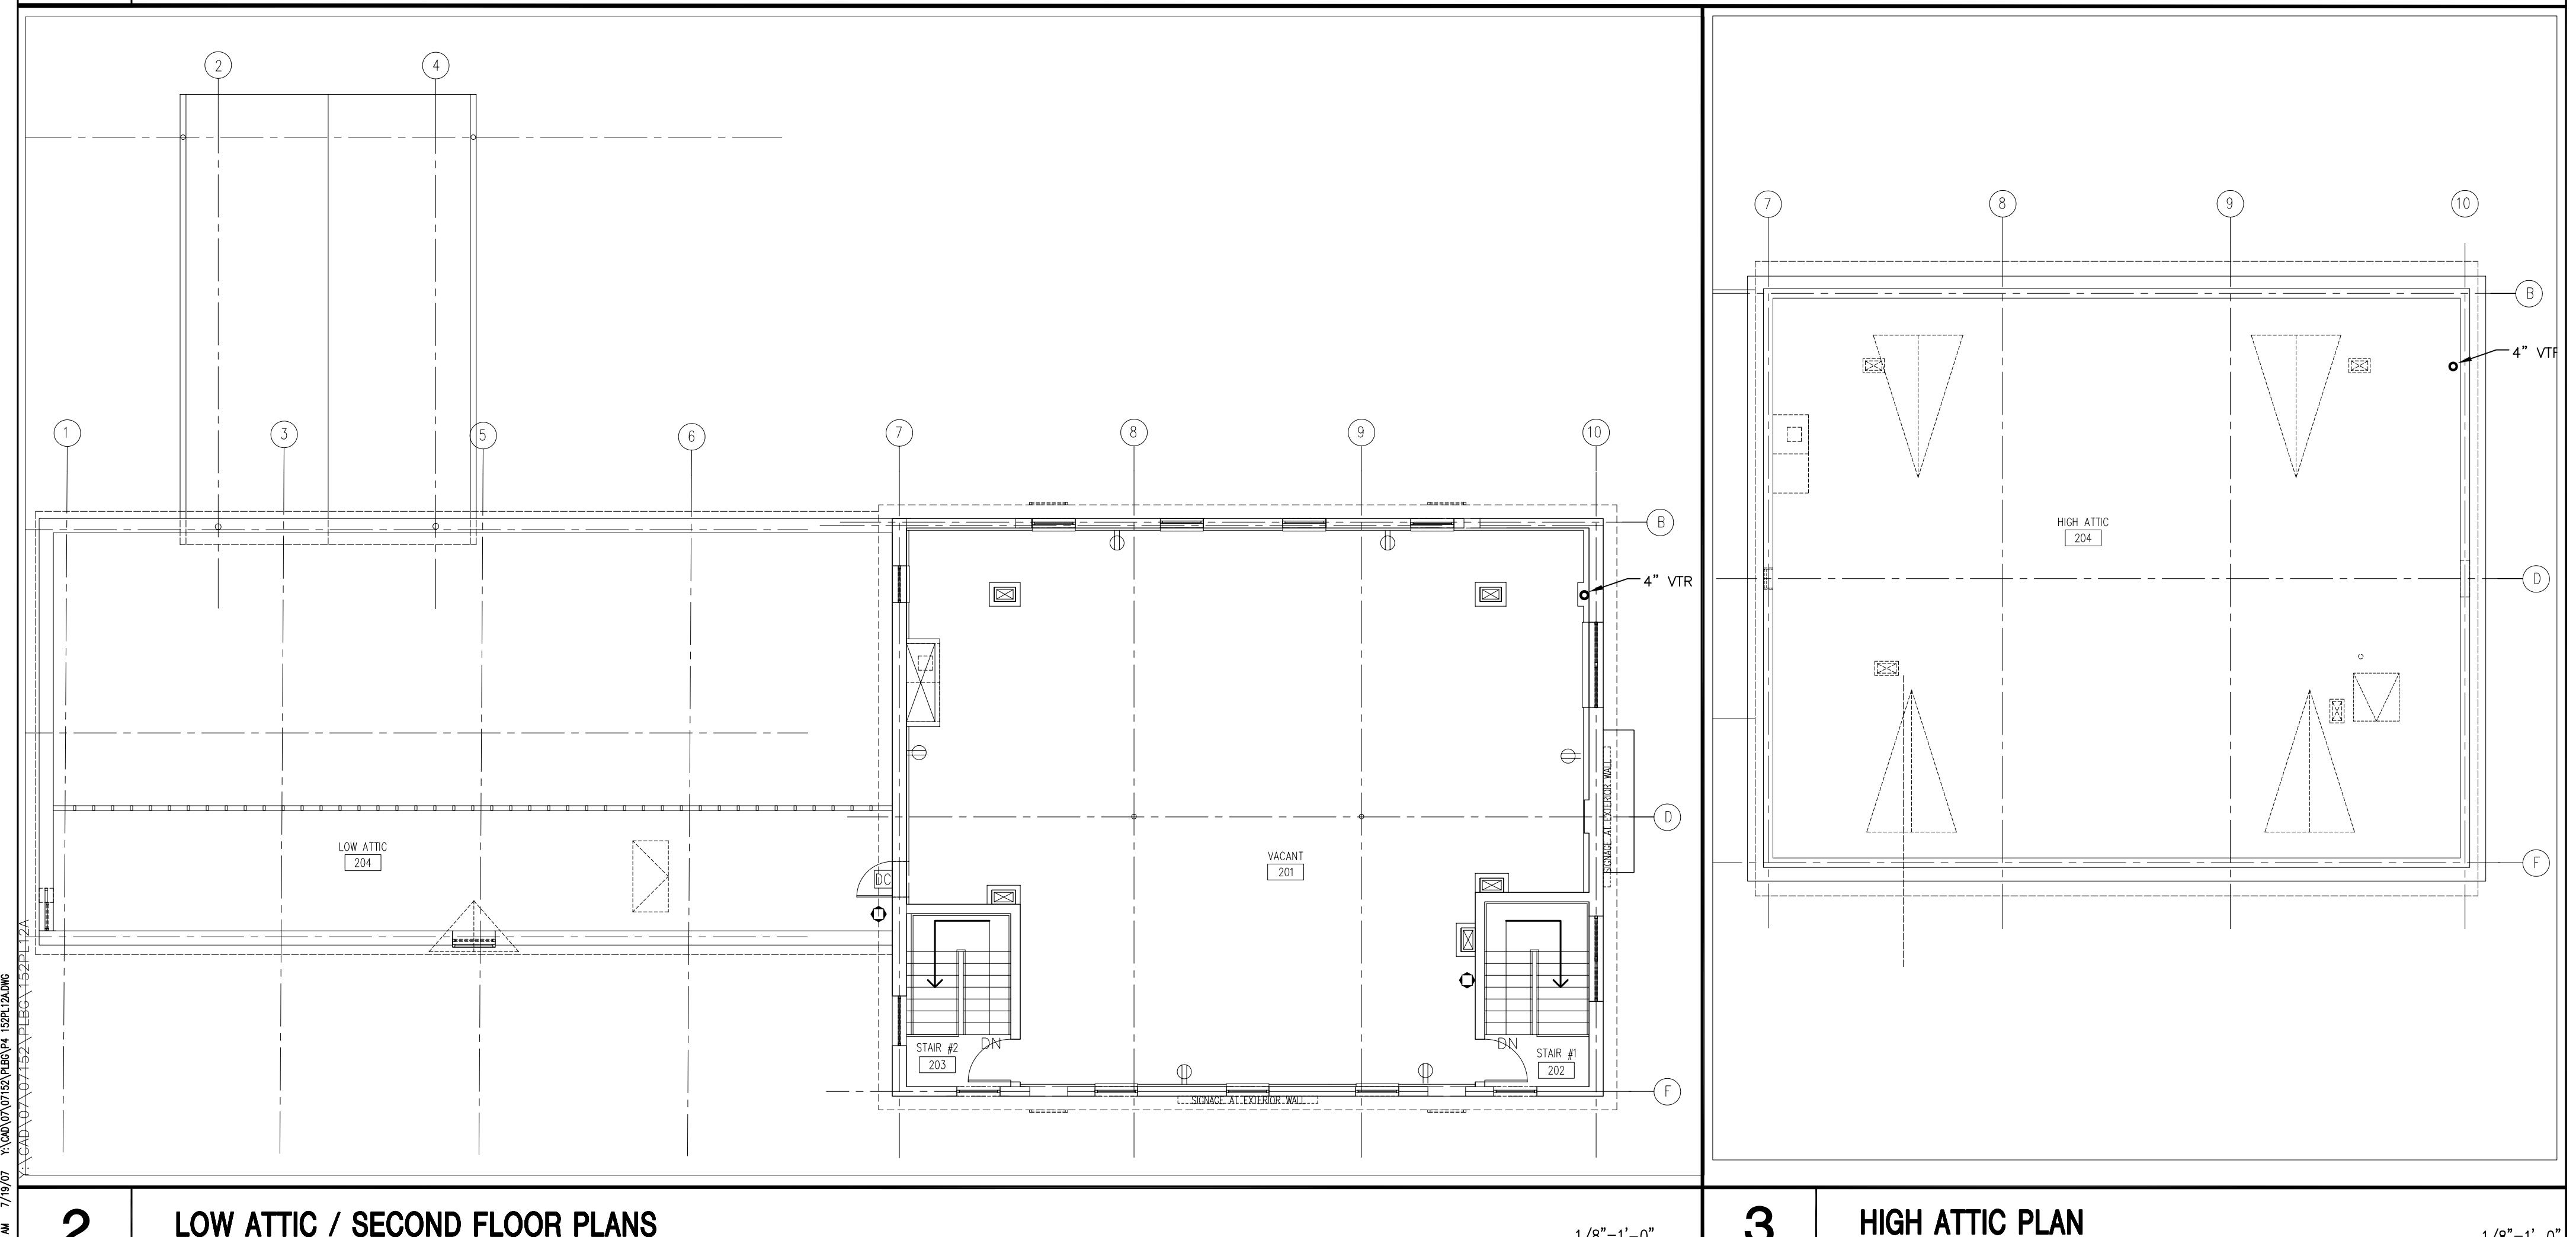

2 LOW ATTIC / SECOND FLOOR PLANS

3 HIGH ATTIC PLAN

1/8"=1'-0"

3 ISSUED FOR BID/LL APPROVAL 07/16/07
2 ISSUED FOR COORDINATION 07/11/07
1 ISSUED FOR BASE 06/19/07

Issue Description Date

IA | **INTERIOR
ARCHITECTS**

NEW YORK

335 MADISON AVENUE, SUITE 305
NEW YORK, NEW YORK 10017
TEL 212-682-6909 FAX 212-867-8852

© 2007 INTERIOR ARCHITECTS NEW JERSEY PC, A NEW JERSEY PROFESSIONAL CORPORATION. ALL DRAWINGS AND WRITTEN MATERIAL HEREIN CONSTITUTE THE ORIGINAL AND UNPUBLISHED WORK OF THE ARCHITECT, AND THE SAME MAY NOT BE DUPLICATED, USED, OR DISCLOSED WITHOUT THE WRITTEN CONSENT OF THE ARCHITECT.

Draw Check Owner Approval
Job No. Scale 1/8"=1'-0"

PLUMBING PLANS

Title _____

**LASZLO BODAK
ENGINEER, P.C.**
45 WEST 30TH STREET • NEW YORK, NY 10018
PHONE: 212-645-1444 • FAX: 212-645-3456

P-4

