




PLUMBING LEGEND	
WASTE PIPING	---
EX-WASTE PIPING	----
COLD WATER	----
EX-COLD WATER	----
HOT WATER	----
HOT WATER RETURN	----
VENT PIPING	----
PIPING TO BE REMOVED	-x-x-x-
N	= NEW
E	= EXISTING
D	= DEMO
⊗	= SHUT-OFF-VALVE (SOV)
⊙	= POINT OF CONNECTION NEW TO EXISTING

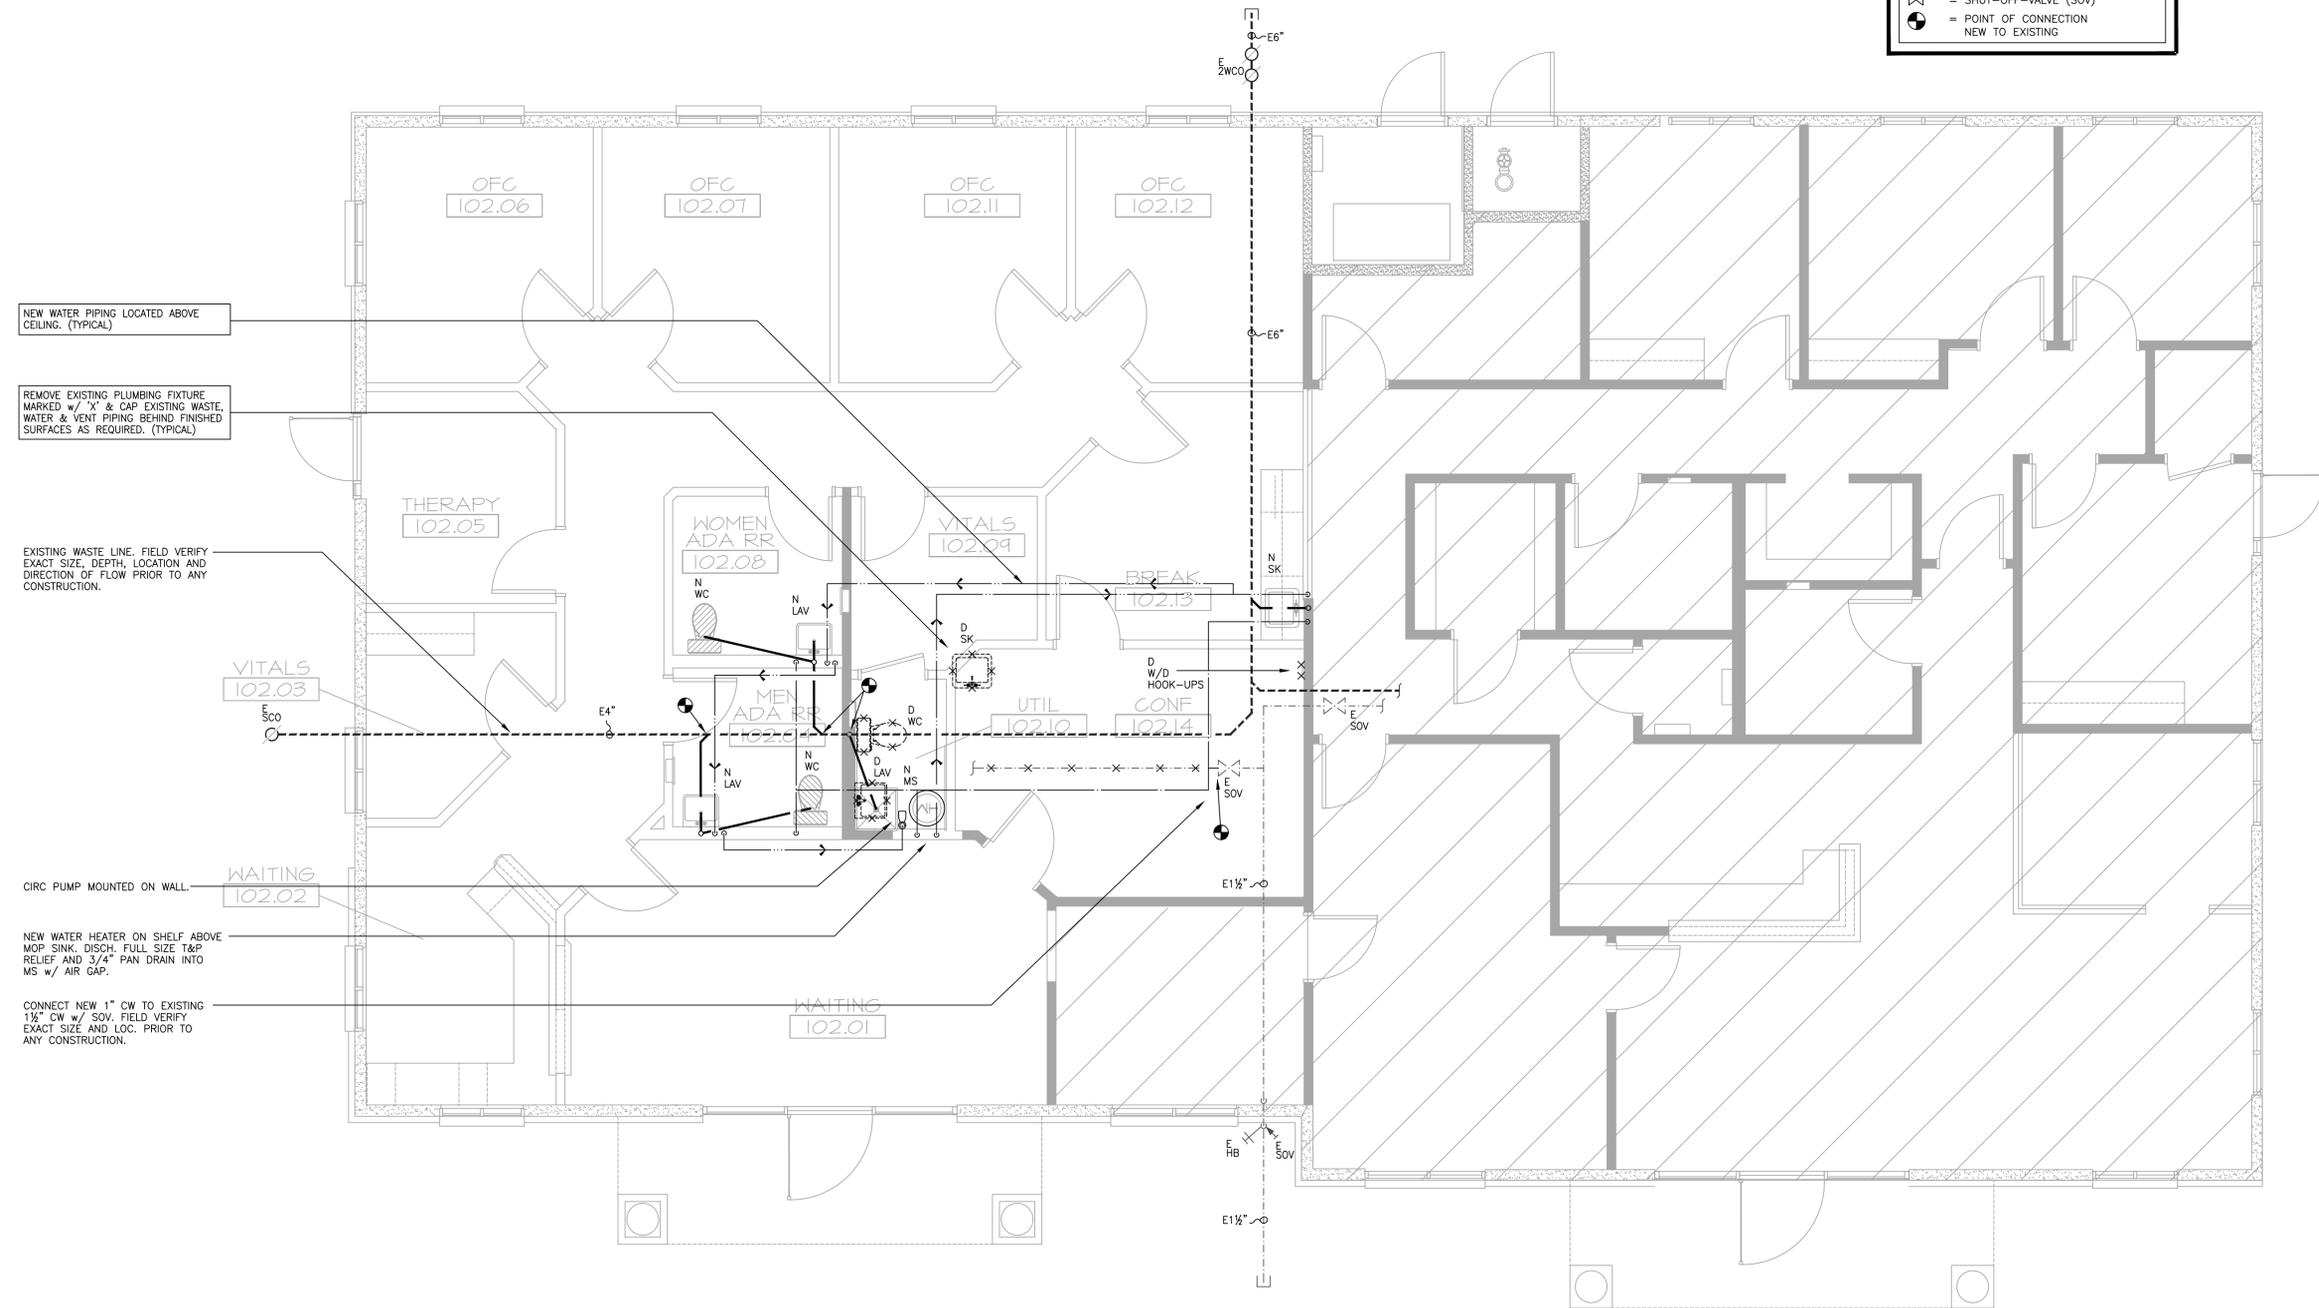

- NEW WATER PIPING LOCATED ABOVE CEILING. (TYPICAL)
- REMOVE EXISTING PLUMBING FIXTURE MARKED w/ 'X' & CAP. EXISTING WASTE, WATER & VENT PIPING BEHIND FINISHED SURFACES AS REQUIRED. (TYPICAL)
- EXISTING WASTE LINE. FIELD VERIFY EXACT SIZE, DEPTH, LOCATION AND DIRECTION OF FLOW PRIOR TO ANY CONSTRUCTION.
- CIRC PUMP MOUNTED ON WALL.
- NEW WATER HEATER ON SHELF ABOVE MOP SINK. DISCH. FULL SIZE T&P RELIEF AND 3/4" PAN DRAIN INTO MS w/ AIR GAP.
- CONNECT NEW 1" CW TO EXISTING 1 1/2" CW w/ SOV. FIELD VERIFY EXACT SIZE AND LOC. PRIOR TO ANY CONSTRUCTION.

PLUMBING FLOOR PLAN

1/8" = 1'-0"

PINAL PROFESSIONAL VILLAGE

BLGD 16: 36457 N. GANTZEL RD. SAN TAN VALLEY, AZ 85140

2nd CHANCE TREATMENT CENTER

PLUMBING FLOOR PLAN

PROJECT:

PROJECT NO: 2125.01
DATE: 11-19-2021
REVISED:

DRAWN BY: JD

SHEET

P.11

OF

