


29'-11"

72'-6"

MAIN STREET

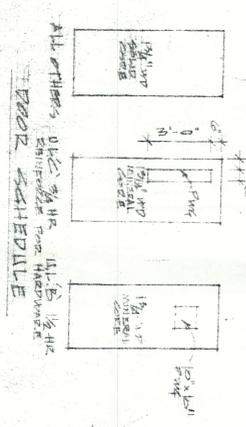


LEGEND

SINGLE POLE SWITCH
 3-WAY SWITCH
 DUPLEX OUTLET
 EMERGENCY SWITCH (HANDICAP TRIPLET OR 3-55A)

HANDICAP ABOVE VISUAL ALARM (3-55A)
 EMERGENCY LIGHTING
 EXIT LIGHT
 SMOKE DETECTOR
 CIRCUIT BREAKER PANEL BOARD
 SMOKE ALARM
 CLOCK

① UL 200 WALL
 ② NO. 11L
 ③

TYPICAL ROOM DIVIDING WALL

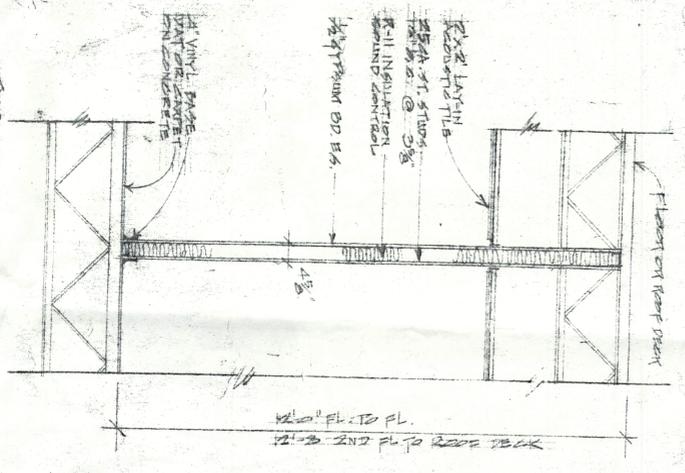

NO.	ISSUE OR REVISION	DATE
1	ELECTRICAL LAYOUT	7-17-04
2	TYPICAL WALL, DOORS, AND	
3	NAMES, LIGHTS, HANDICAP	
4	EXIT LIGHTS	



SECOND FLOOR PLAN DEESES FOR
 DR. VINCENT MANTONE
 2700 MAIN STREET, BRIDGEPORT, CT

A.J. PALMIERI ARCHITECT & ASSOCIATES P.C.
 2546 MAIN STREET
 BRIDGEPORT, CONNECTICUT 06606

OFFICE LAYOUT & ELECTRICAL		L1:1
DATE	SCALE	JOB NO.
7-17-04	1/8" = 1'-0"	85-280
DRAWN BY	CHECKED BY	