

PERMIT PACKAGE

PREMIERE CINEMAS
 at Eastern Shore Centre
 Spanish Fort, Alabama



CMH Architects
 1800 International Park Drive
 Suite 300
 Birmingham, AL 35243
 (205)969-2696 - TEL
 (205)969-3920 - FAX
 www.cmharch.com

Copyright © 2006 CMH Architects

REVISIONS

02/27/08 CBH1

SHEET TITLE
CODE COMPLIANCE PLAN


PROJECT NUMBER
 892
ISSUE DATE
 12/11/07
DRAWN BY
 LA
CHECKED BY
 MOK

SHEET NUMBER
A0.6

PREMIERE CINEMAS


SYMBOL LEGEND

-  Fire Exit/Exit Width Provided
-  Fire Extinguisher Cabinet (Coordinate w/ fire marshal)
-  Fire Exit Sign (Arrow indicates direction of travel/shaded area indicates face of signage)
-  High/Low Drinking Fountains

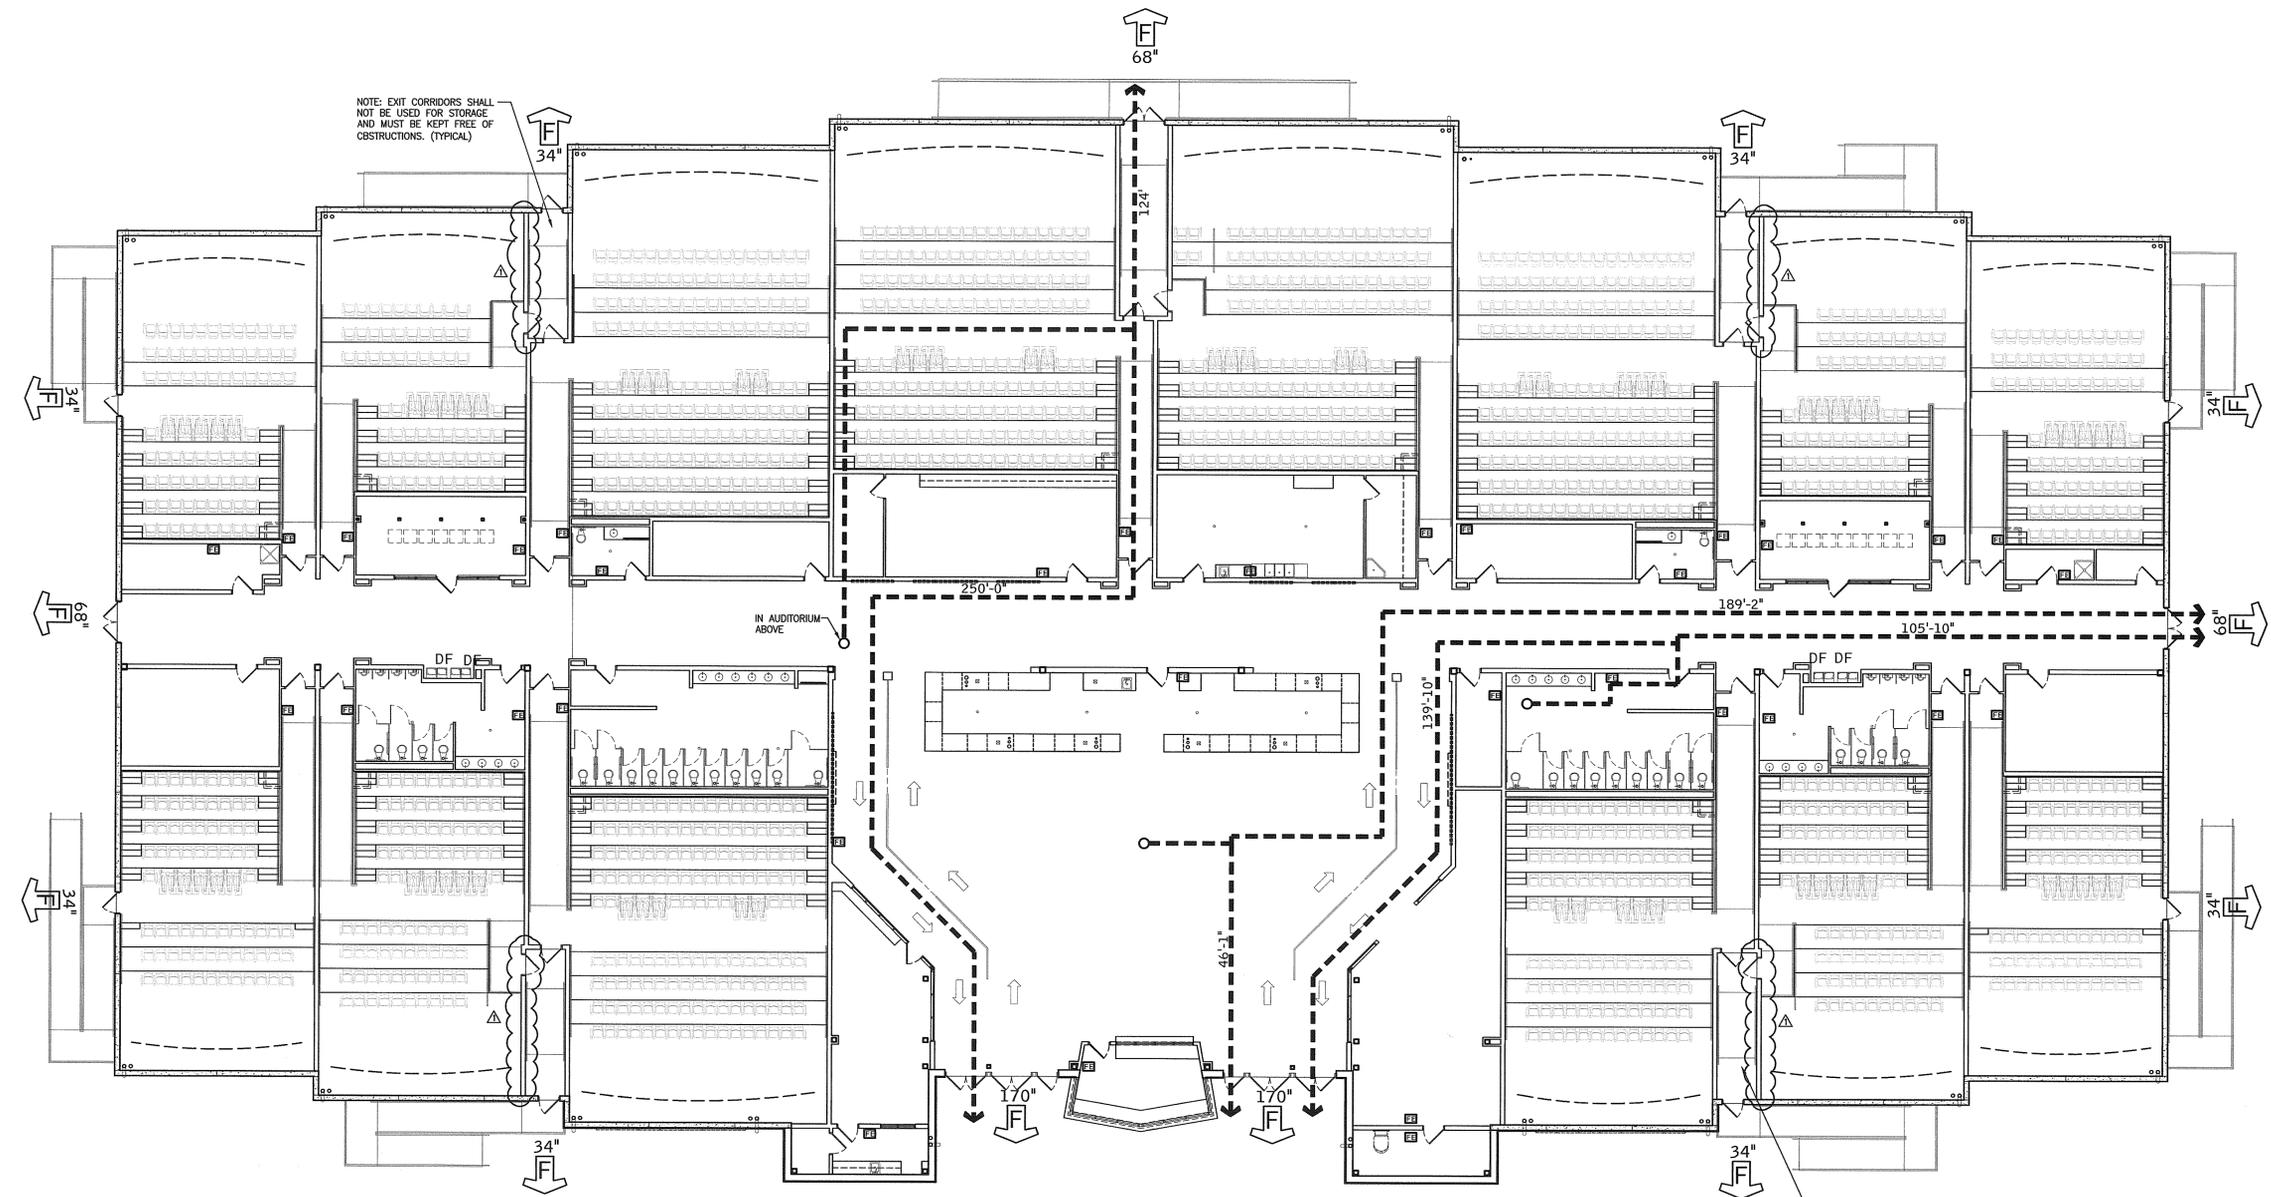


- PROVIDE AT LEAST ONE KNOX BOX FOR THIS BUILDING, LOCATED AS PER DIRECTION FROM THE FIRE MARSHAL
- THIS BUILDING SHALL BE EQUIPPED WITH A FULLY OPERATIONAL AUTOMATIC FIRE SPRINKLER SYSTEM.
- THIS BUILDING SHALL BE EQUIPPED WITH A FULLY OPERATIONAL FIRE ALARM SYSTEM.
- 2,666 TOTAL OCCUPANTS
- 2,666 x 0.15 = 400' OF EGRESS WIDTH REQUIRED
- TOTAL EGRESS WIDTH PROVIDED = 816'
- 44,965 SF GROSS BUILDING AREA
- 44,965 SF / 3000 = 15 FIRE EXTINGUISHERS REQUIRED
- NUMBER OF FIRE EXTINGUISHERS PROVIDED = 33

01
0.6
CODE COMPLIANCE PLAN
 3/32" = 1'-0"

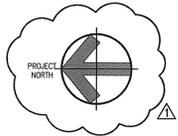

PLOT DATE: 2/25/2008 10:56 AM
 P:\892 Premiere Theater at ESC\dwg\892A0-A6 CB.dwg

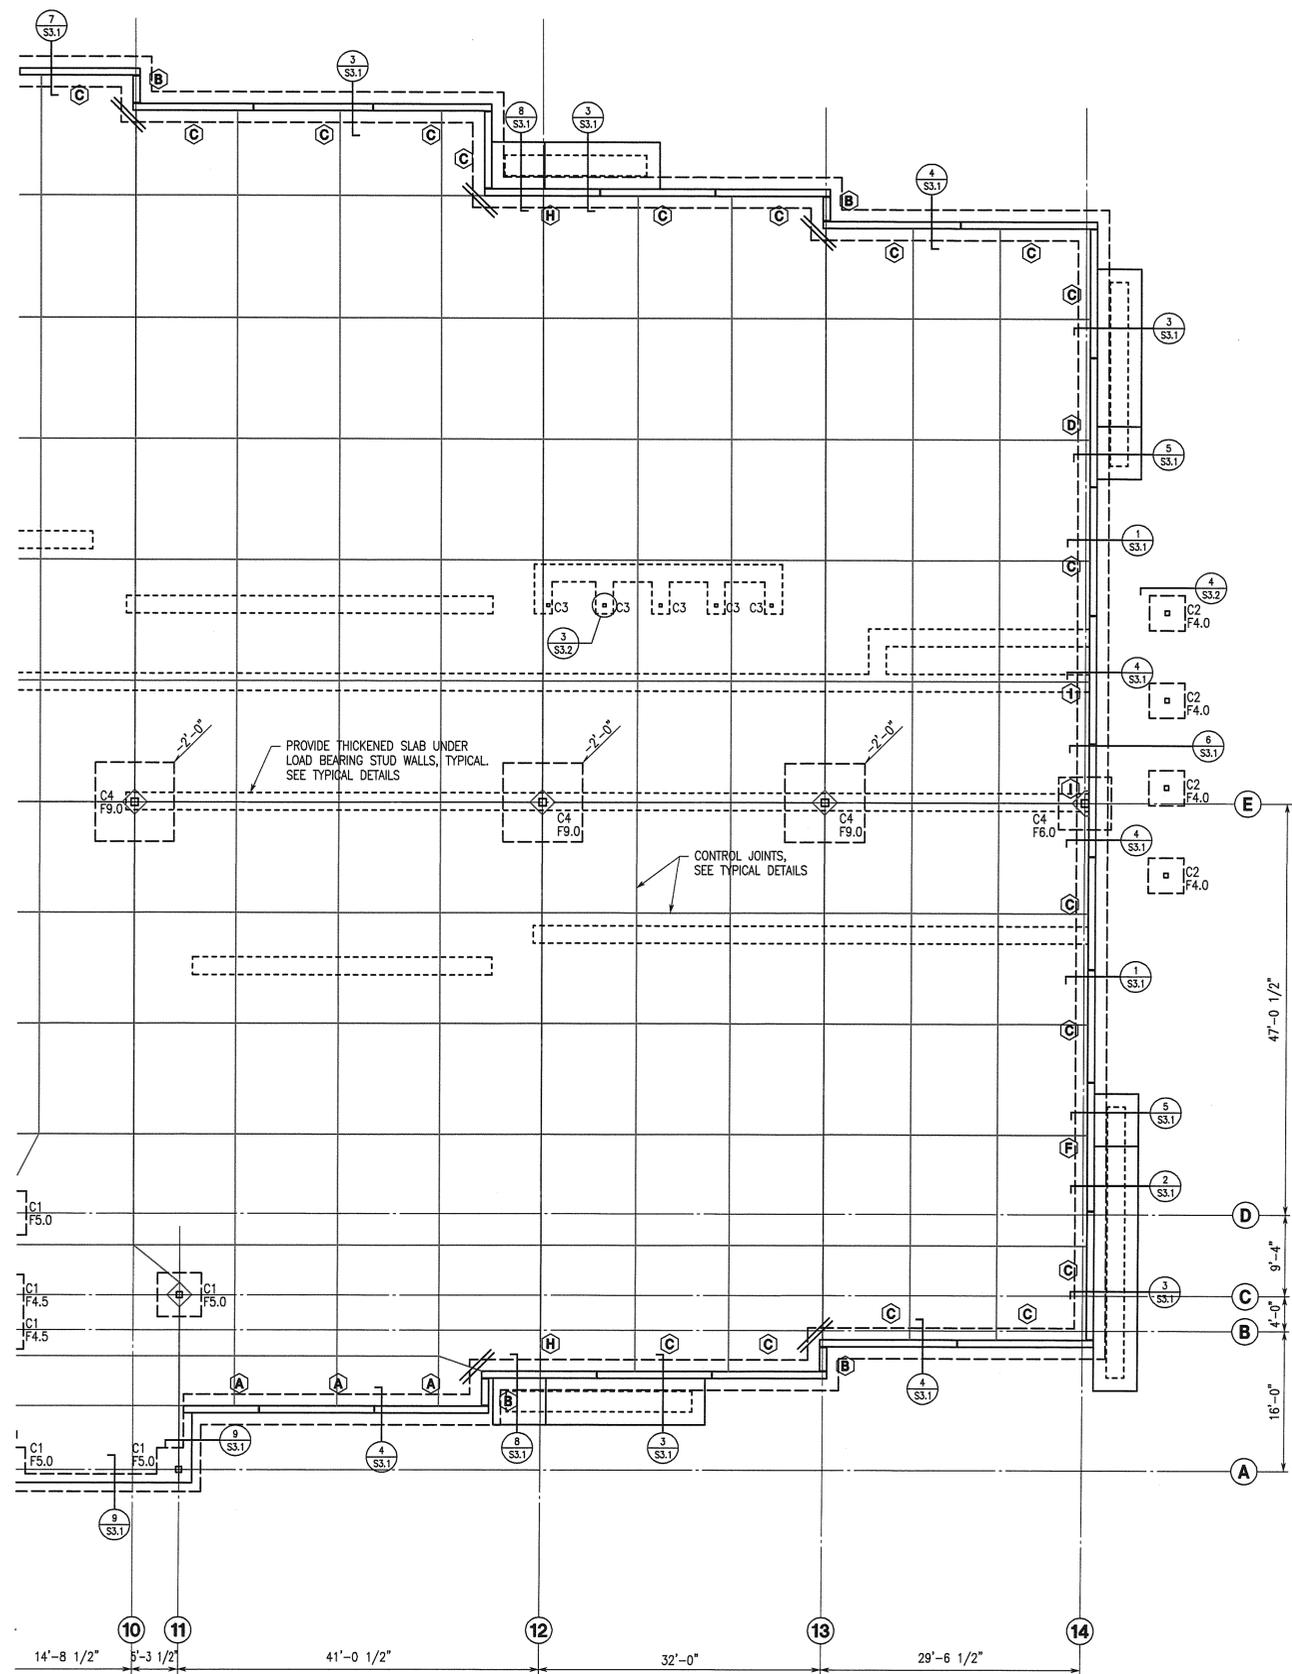

COLUMN SCHEDULE				
COLUMN DESIGNATION	C1	C2	C3	C4
SIZE	HSS 8x8x1/2	HSS 6x6x1/4	HSS 4x4x1/4	HSS 10x10x3/8
BASE PLATE	3/4x14x14	3/4x12x12	3/4x10x10	3/4x16x16
ANCHOR RODS	(4) 3/4" W/ 9" EMBEDMENT			
NOTES				

FOOTING SCHEDULE					
FOOTING DESIGNATION	F4.5	F5.0	F6.0	F9.0	
SIZE (LxW)	4'-6"x4'-6"	5'-0"x5'-0"	6'-0"x6'-0"	9'-0"x9'-0"	
DEPTH (D)	1'-0"	1'-0"	1'-2"	2'-0"	
REINF EW (BOT)	4#5	5#5	6#5	10#6	
NOTES					

NOTES:
1. PROVIDE SCHEDULED REINFORCEMENT ON TOP AND BOTTOM OF FOOTING.



FOUNDATION PLAN - NORTH

- 1/8"=1'-0"
- FINISH FLOOR (TOP OF SLAB) ELEVATION 0'-0", UNLESS NOTED.
 - TOP OF FOOTING ELEVATION -3'-0", UNLESS NOTED.
 - FOR SLAB ON GRADE CONSTRUCTION, SEE GENERAL NOTES AND TYPICAL DETAILS.
 - FOR SLAB RECESS AND RAMP LOCATIONS, SEE ARCHITECTURAL DRAWINGS.
 - GENERAL CONTRACTOR SHALL COORDINATE TILE JOINT LOCATIONS WITH CONTROL JOINTS.
 - FOOTING STEP LOCATIONS SHOWN ARE APPROXIMATE. GENERAL CONTRACTOR COORDINATE LOCATION OF ALL FOOTING STEPS WITH THE LATEST CIVIL, PLUMBING AND UTILITY DRAWINGS.
 - ⊙ INDICATES PANEL DESIGN DESIGNATION.
 - SEE S4.1 FOR DETAILS OF SEATING.

SHELL PERMIT PACKAGE

PREMIERE CINEMAS
at Eastern Shore Centre
Spanish Fort, Alabama



CMH Architects
1800 International Park Drive
Suite 300
Birmingham, AL 35243
(205)969-2696 - TEL
(205)969-3930 - FAX
www.cmharch.com

Copyright © 2007 CMH Architects

REVISIONS

NO.	DATE	DESCRIPTION

SHEET TITLE
FOUNDATION PLAN NORTH

PROJECT NUMBER
892.00

ISSUE DATE
10/31/07

DRAWN BY
ABS

CHECKED BY
SSE

SHEET NUMBER

S2.1b

PREMIERE CINEMAS




SHELL PERMIT PACKAGE

PREMIERE CINEMAS
at Eastern Shore Centre
Spanish Fort, Alabama

CMH Architects
1800 International Park Drive
Suite 300
Birmingham, AL 35243
(205)969-2696 - TEL
(205)969-2930 - FAX
www.cmharch.com
Copyright © 2007 CMH Architects

REVISIONS

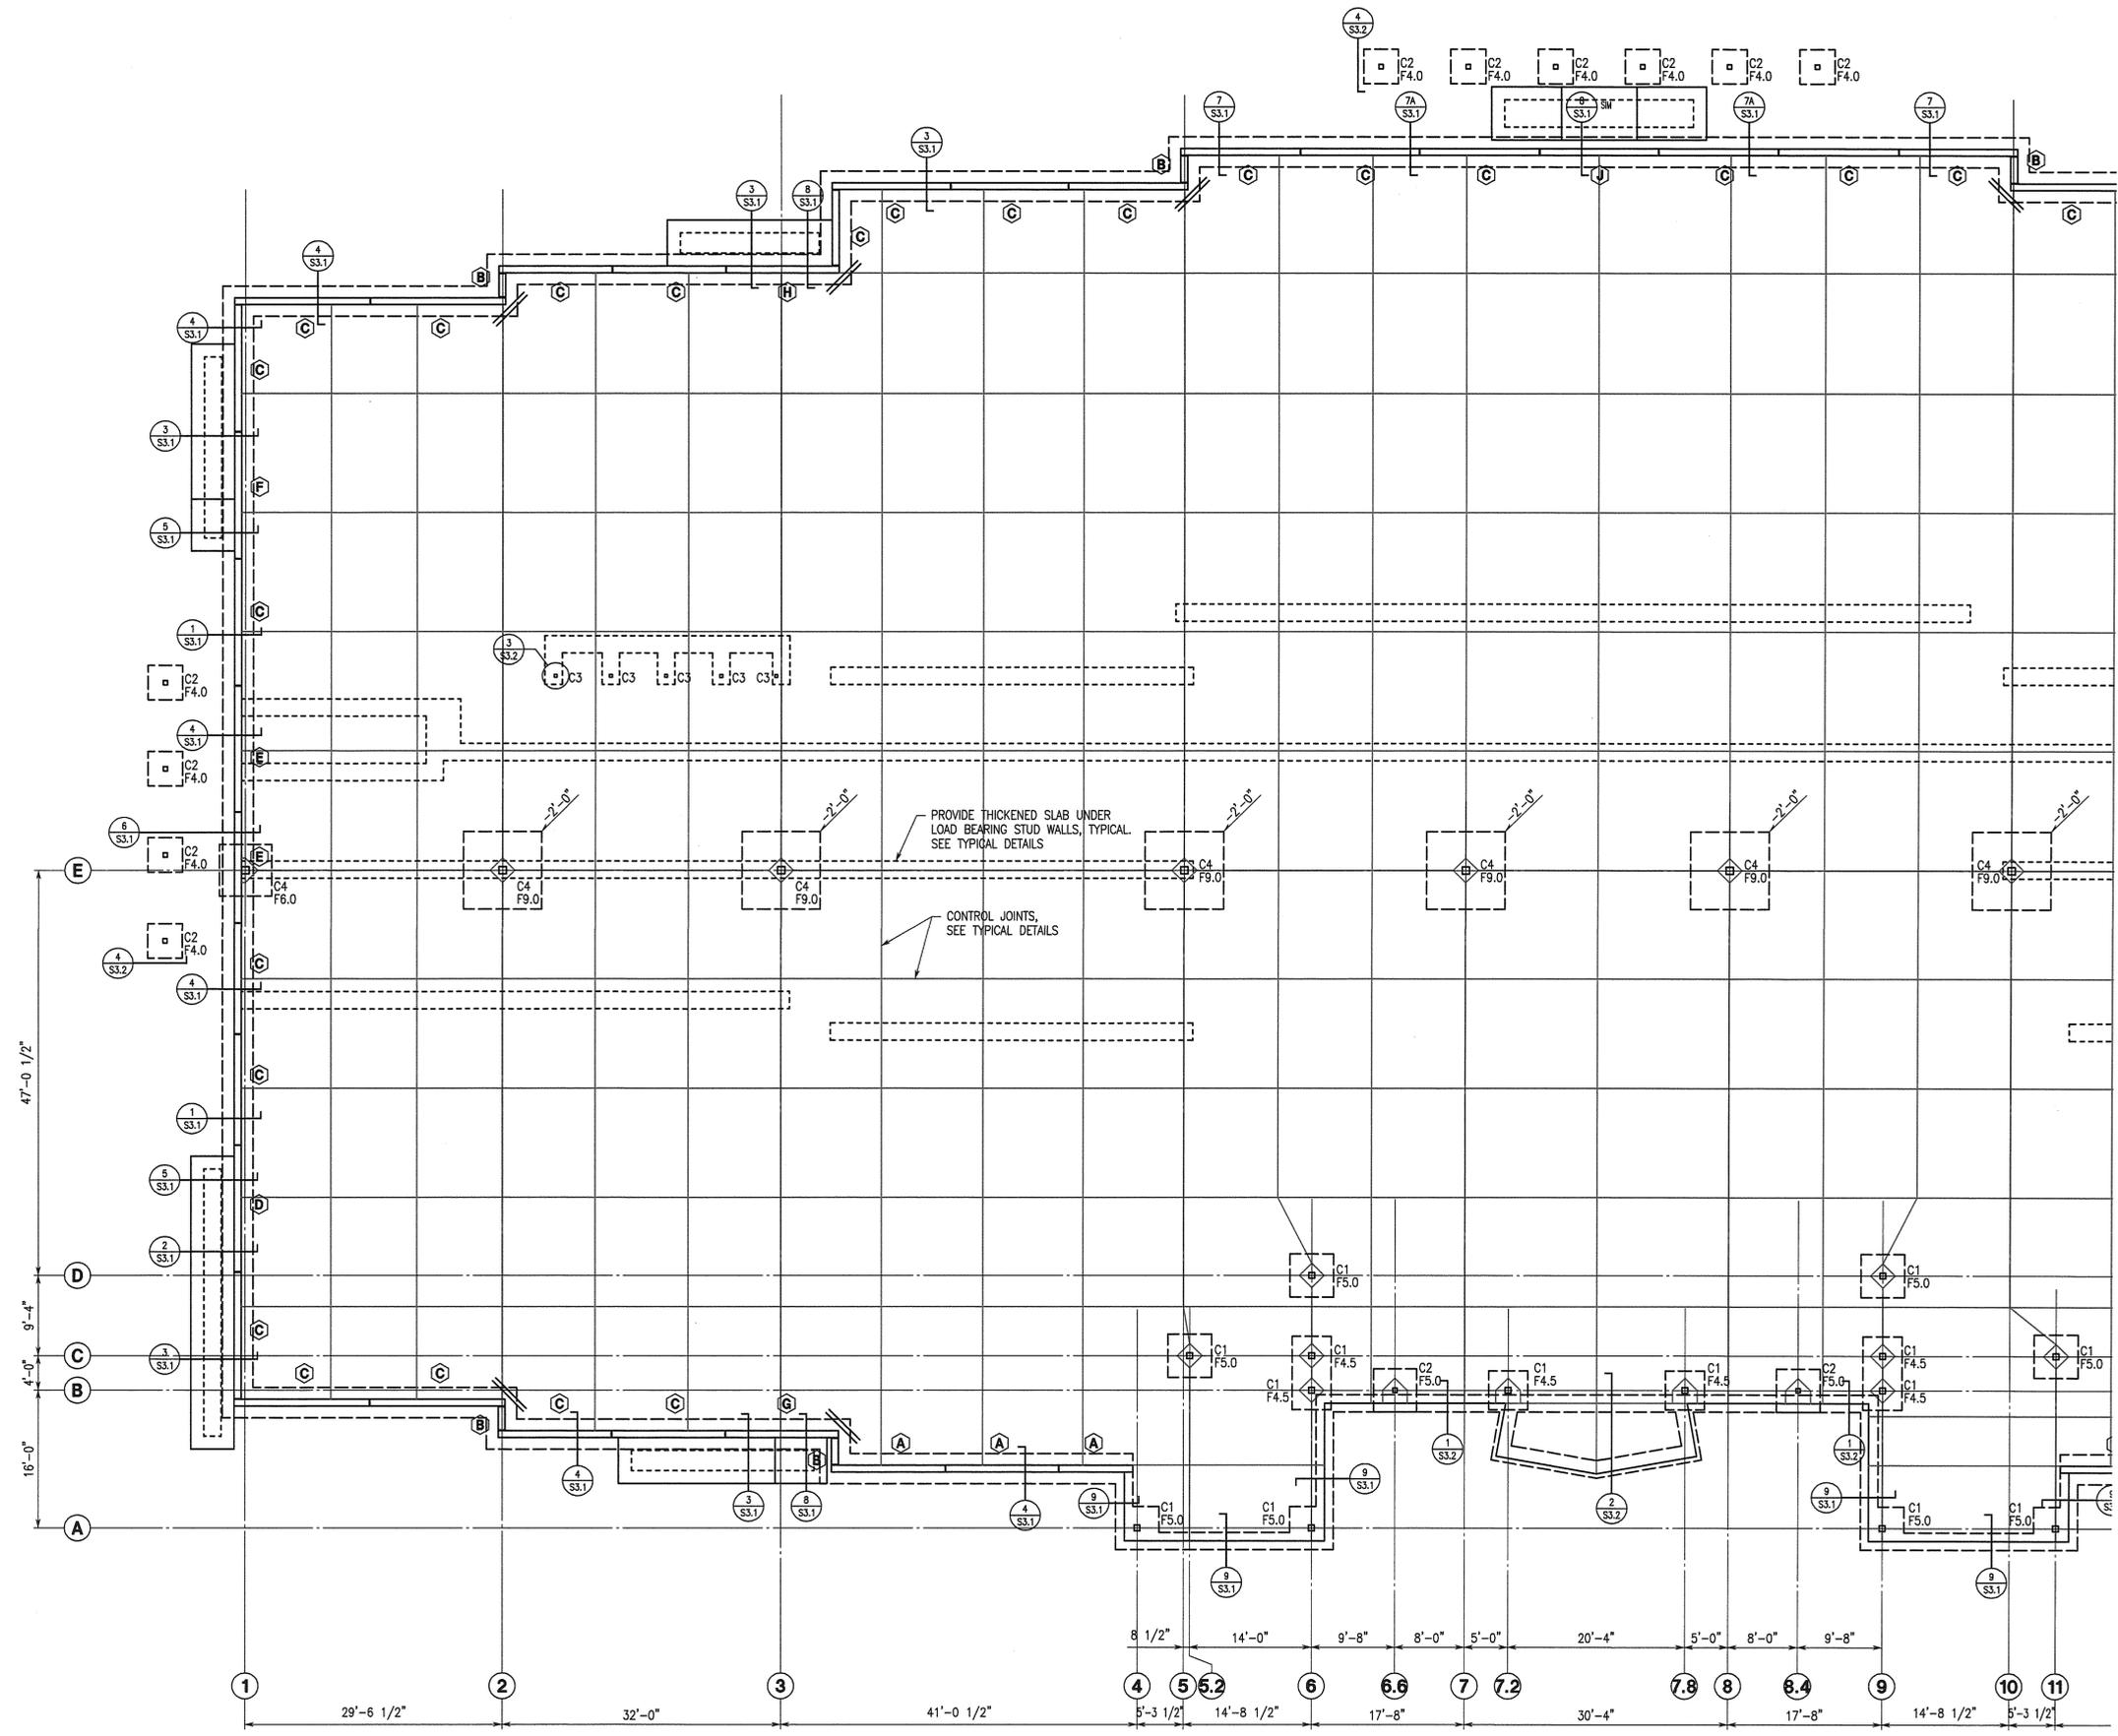

- PROJECT NORTH
- FOUNDATION PLAN - SOUTH**
1/8"=1'-0"
1. FINISH FLOOR (TOP OF SLAB) ELEVATION 0'-0", UNLESS NOTED.
 2. TOP OF FOOTING ELEVATION -3'-0", UNLESS NOTED.
 3. FOR SLAB ON GRADE CONSTRUCTION, SEE GENERAL NOTES AND TYPICAL DETAILS.
 4. FOR SLAB RECESS AND RAMP LOCATIONS, SEE ARCHITECTURAL DRAWINGS.
 5. GENERAL CONTRACTOR SHALL COORDINATE TILE JOINT LOCATIONS WITH CONTROL JOINTS.
 6. FOOTING STEP LOCATIONS SHOWN ARE APPROXIMATE. GENERAL CONTRACTOR COORDINATE LOCATION OF ALL FOOTING STEPS WITH THE LATEST CIVIL, PLUMBING AND UTILITY DRAWINGS.
 7. ⊗ INDICATES PANEL DESIGN DESIGNATION.
 8. SEE S4.1 FOR DETAILS OF SEATING.

SHEET TITLE
FOUNDATION PLAN SOUTH

PROJECT NUMBER
892.00


ISSUE DATE
10/31/07

DRAWN BY
ABS

CHECKED BY
SSE

SHEET NUMBER
S2.1a

PREMIERE CINEMAS

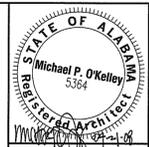

PERMIT PACKAGE

PREMIERE CINEMAS
at Eastern Shore Centre
Spanish Fort, Alabama


CMH ARCHITECTS
1830 International Park Drive
Suite 300
Birmingham, AL 35243
(205) 969-9696 - TEL
(205) 969-3930 - FAX
www.cmharch.com

REVISIONS
02/21/08 CBH1
04/21/08 CBH2


SHEET TITLE
AUDITORIUM PLANS AND SECTIONS

PROJECT NUMBER
892
ISSUE DATE
12/11/07
DRAWN BY
MOK, LA
CHECKED BY
MOK


SHEET NUMBER
A6.1
PREMIERE CINEMAS

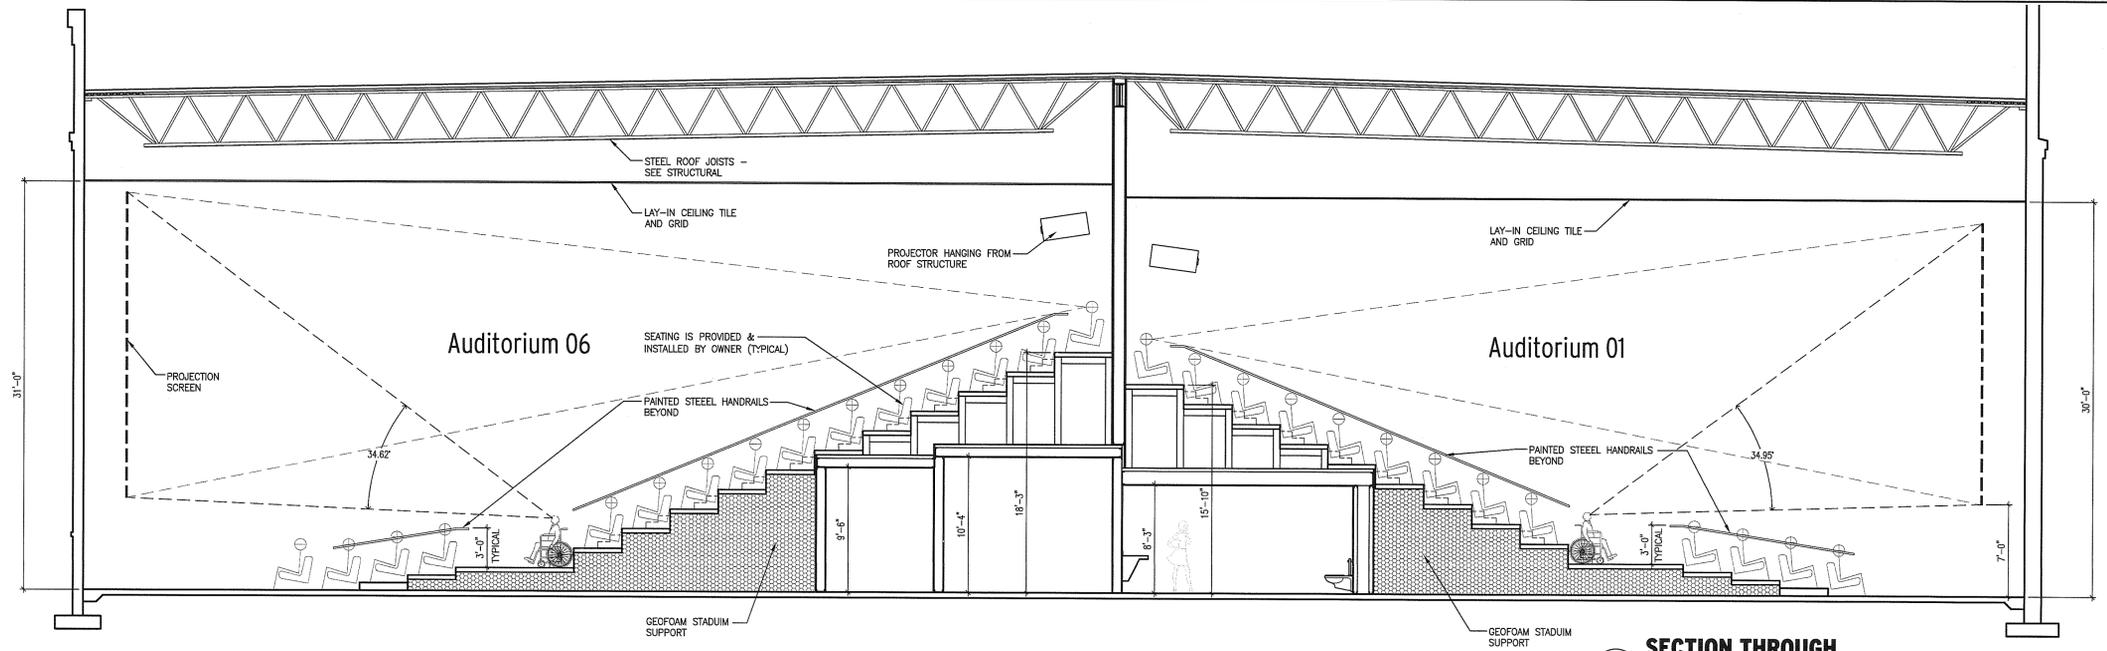


03
6.1 SECTION THROUGH AUDITORIUMS 01 AND 06
3/16" = 1'-0"

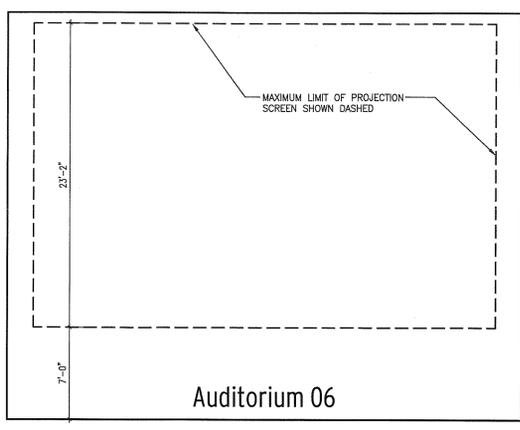


05
6.1 SECTION THROUGH AUDITORIUM 06
3/16" = 1'-0"

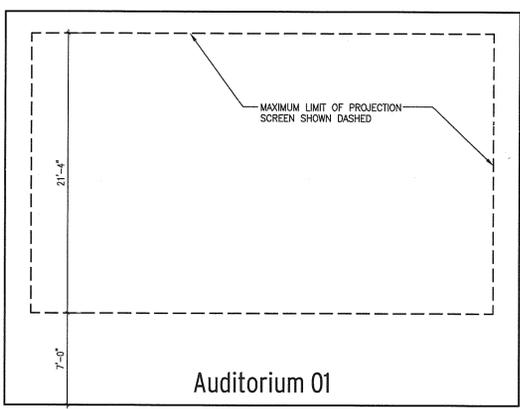

04
6.1 SECTION THROUGH AUDITORIUM 01
3/16" = 1'-0"

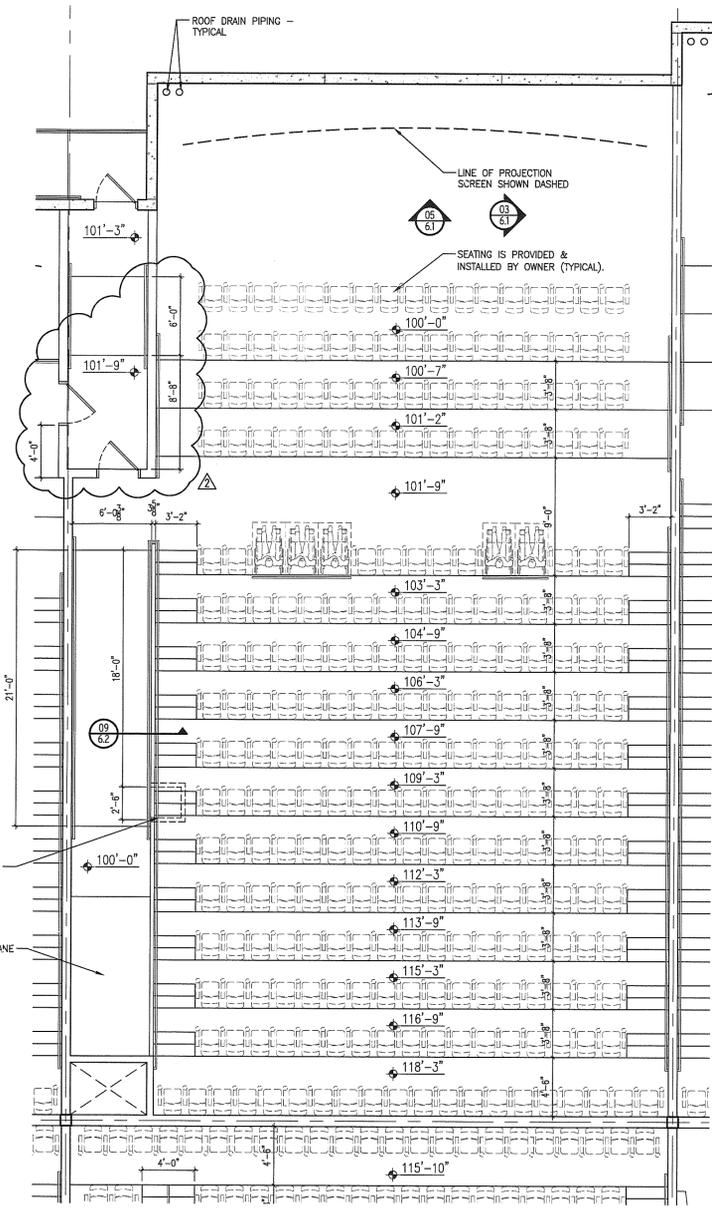

02
6.1 ENLARGED PLAN AT AUDITORIUM 06
3/16" = 1'-0"

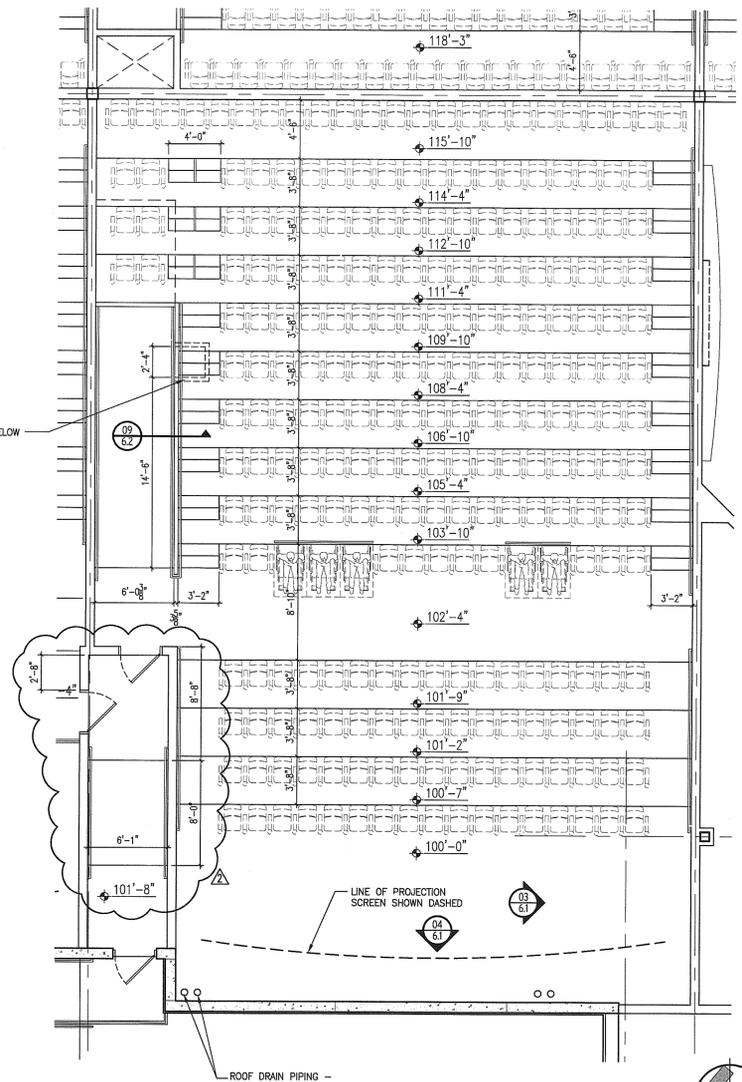

01
6.1 ENLARGED PLAN AT AUDITORIUM 01
3/16" = 1'-0"

PLOT DATE: 4/21/2008 2:35 PM P:\892 Premier Theater at ESC\dwg\892A6-01 CB2.dwg

