


① FIRST FLOOR EQUIPMENT PLAN
1/4" = 1'

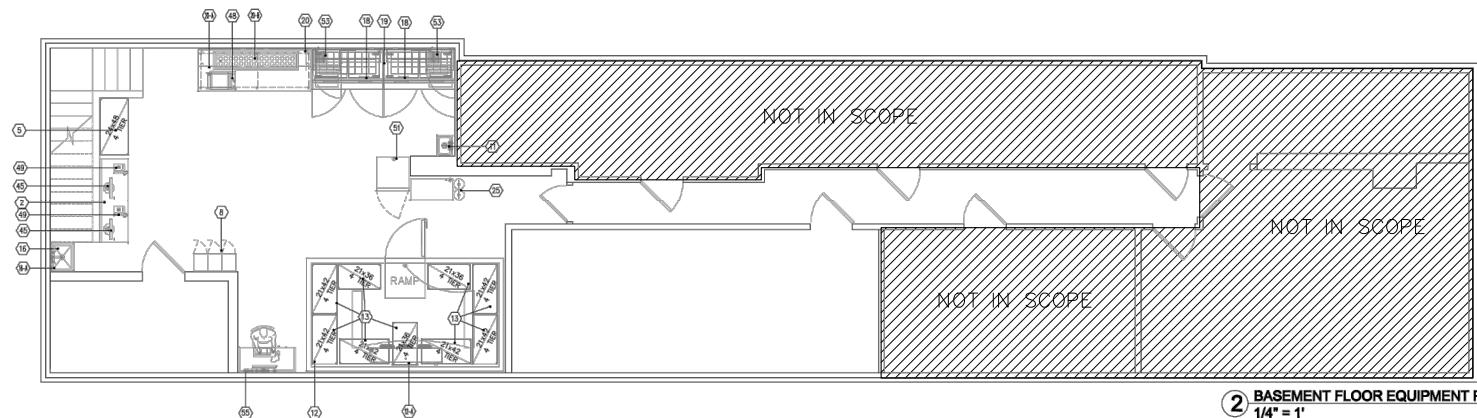

② BASEMENT FLOOR EQUIPMENT PLAN
1/4" = 1'

EQUIPMENT SCHEDULE

MC	QTY	DESCRIPTION	MC	QTY	DESCRIPTION	MC	QTY	DESCRIPTION
1	1	SINK, TWO COMPARTMENT	12	1	WALK-IN COOLER	20-B	1	DRESSING HOLDER
2	1	REFRIGERATOR, UPRIGHT	13	1	WALK-IN COOLER	32	-	SPARE NUMBER -
3	1	SUS WALL SHELF	13-B	1	REMOTE CONDENSING UNIT	40	-	SPARE NUMBER -
4	1	SUS WORK TABLE	13	1	POS SYSTEM	41	1	SPARE SPANNER
5	1	SHELVING UNIT	13	1	REFRIGERATED MERCHANDISER	48	3	PANINI GRILL
6	1	SHELVING UNIT	14	2	REFRIGERATION UNIT	49	2	TELEPHONE
7	1	SHELVING UNIT	14	3	REFRIGERATED COUNTER, PAN TOP	50	-	SPARE NUMBER -
7	1	MICROWAVE OVEN	15	1	REFRIGERATED COUNTER, RAISED RAIL	50	-	SPARE NUMBER -
7-A	1	MICROWAVE SHELF	15	1	REFRIGERATED COUNTER, RAISED RAIL	51	1	SPARE NUMBER -
8	1	LOCKERS, 18-CAPACITY	15-A	1	MOP HANGER	52	-	SPARE NUMBER -
9	1	PRE-RINSE SPRAY RINFACET	17	1	- SPARE NUMBER -	52	2	REFRIGERATION SYSTEM, REMOTE
9-A	1	PRE-RINSE SPRAY RINFACET	17-A	2	REFRIGERATION SYSTEM, REMOTE	40	1	BEVERAGE COUNTER
10	1	SUS WALL SHELF	18	1	SUS WORK COUNTER, SANDWICH TOP	54	2	CONDIMENT/TRASH UNIT
10	2	SUS WORK TABLE	19	1	SUS WORK COUNTER, SANDWICH TOP	55	1	COMPUTER STATION
11	2	HAND SINK	20	1	SUS WORK TABLE	55-A	1	ICE MAKER, CUBE-STYLE
			20-A	1	SUS WORK TABLE, MOUNT, DOUBLE	42	1	STEAM COOLER
			31	2	FOOD WARMER/COOKER, COUNTERTOP	42-A	1	WATER FILTER ASSEMBLY
				30	-	55-B	1	EVAPORATOR COIL
				30	-	56-A	1	REMOTE CONDENSING UNIT
				43	-	56-B	1	POUNT OF SALE SYSTEM
				45	2			

E F G H

64 W 25TH STREET PLAZA
MANHATTAN, NEW YORK, USA
TEL: (212) 619-6100
FAX: (212) 619-6102

PROJECT:
CHOP'T
16 West 25th Street, New York, NY 10010

TITLE:
EQUIPMENT FLOOR PLANS

REVISION	DATE

SCALE:
1/4" = 1'

DATE:
01-23-12

SHEET:
A-105

NYC DOB NUMBER: **PAGE:**