

RYNACLE WEISSER
ARCHITECTS

CONTRACTOR:
SPENCER HATCH
DOUBLE HOMES

DOUBLE HOMES

NO.	DESCRIPTION	DATE	BY	CHKD
D1.0	MECHANICAL INFO.	2/20/14		
D1.1	FLOOR PLAN	2/27/14		
D1.2	MECHANICAL	2/27/14		
D1.3	MECHANICAL	2/27/14		
D1.4	MECHANICAL	2/27/14		
D1.5	MECHANICAL	2/27/14		
D1.6	MECHANICAL	2/27/14		
D1.7	MECHANICAL	2/27/14		
D1.8	MECHANICAL	2/27/14		
D1.9	MECHANICAL	2/27/14		
D1.10	MECHANICAL	2/27/14		
D1.11	MECHANICAL	2/27/14		
D1.12	MECHANICAL	2/27/14		
D1.99	MECHANICAL	2/27/14		
D1.100	MECHANICAL	2/27/14		

ULTIMATE REALTY OFFICE

RCP / ELECTRICAL

SHEET TITLE

PROJECT TITLE

DATE: MARCH 24, 2014

SCALE: 1/4" = 1'-0"

OWNER: SPENCER HATCH

PROJECT ADDRESS: OAK CENTER

PROJECT NUMBER: OAK-101


DATE: MARCH 24, 2014

SCALE: 1/4" = 1'-0"

SHEET NUMBER: D1.3

5 4 3 2 1

A B C D E

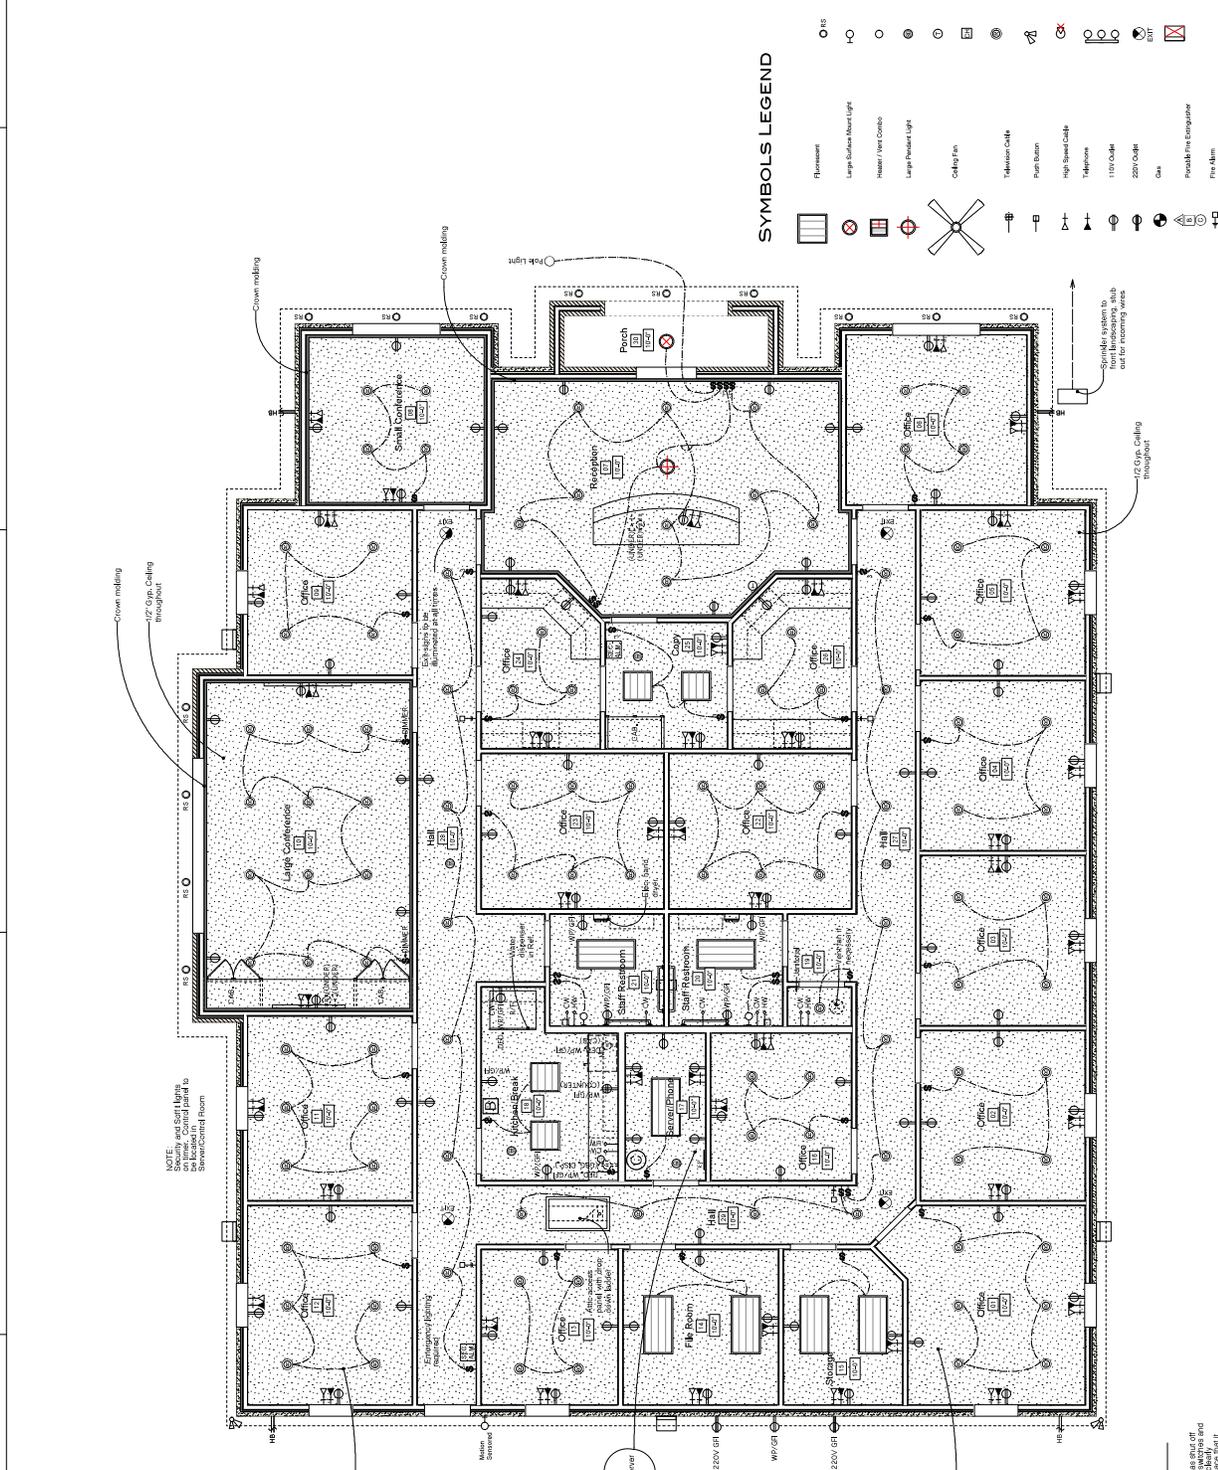

NOTE: Showing and Staff Light to be located in the Manufacturing Room

NOTE: Electrical to work Server and Telephone Equipment

NOTE: Electrical to verify AC Unit

NOTE: 12\"/>

E3 RCP / Electrical Plan
Scale: 1/4" = 1'-0"

NOTE: Utility locations by the architect. Values, electrical symbols, and notes are for information only. The architect is not responsible for the accuracy of the information provided. The architect is not responsible for the accuracy of the information provided. The architect is not responsible for the accuracy of the information provided.

© 2014 Rynacle Weisser Design