



## General Notes

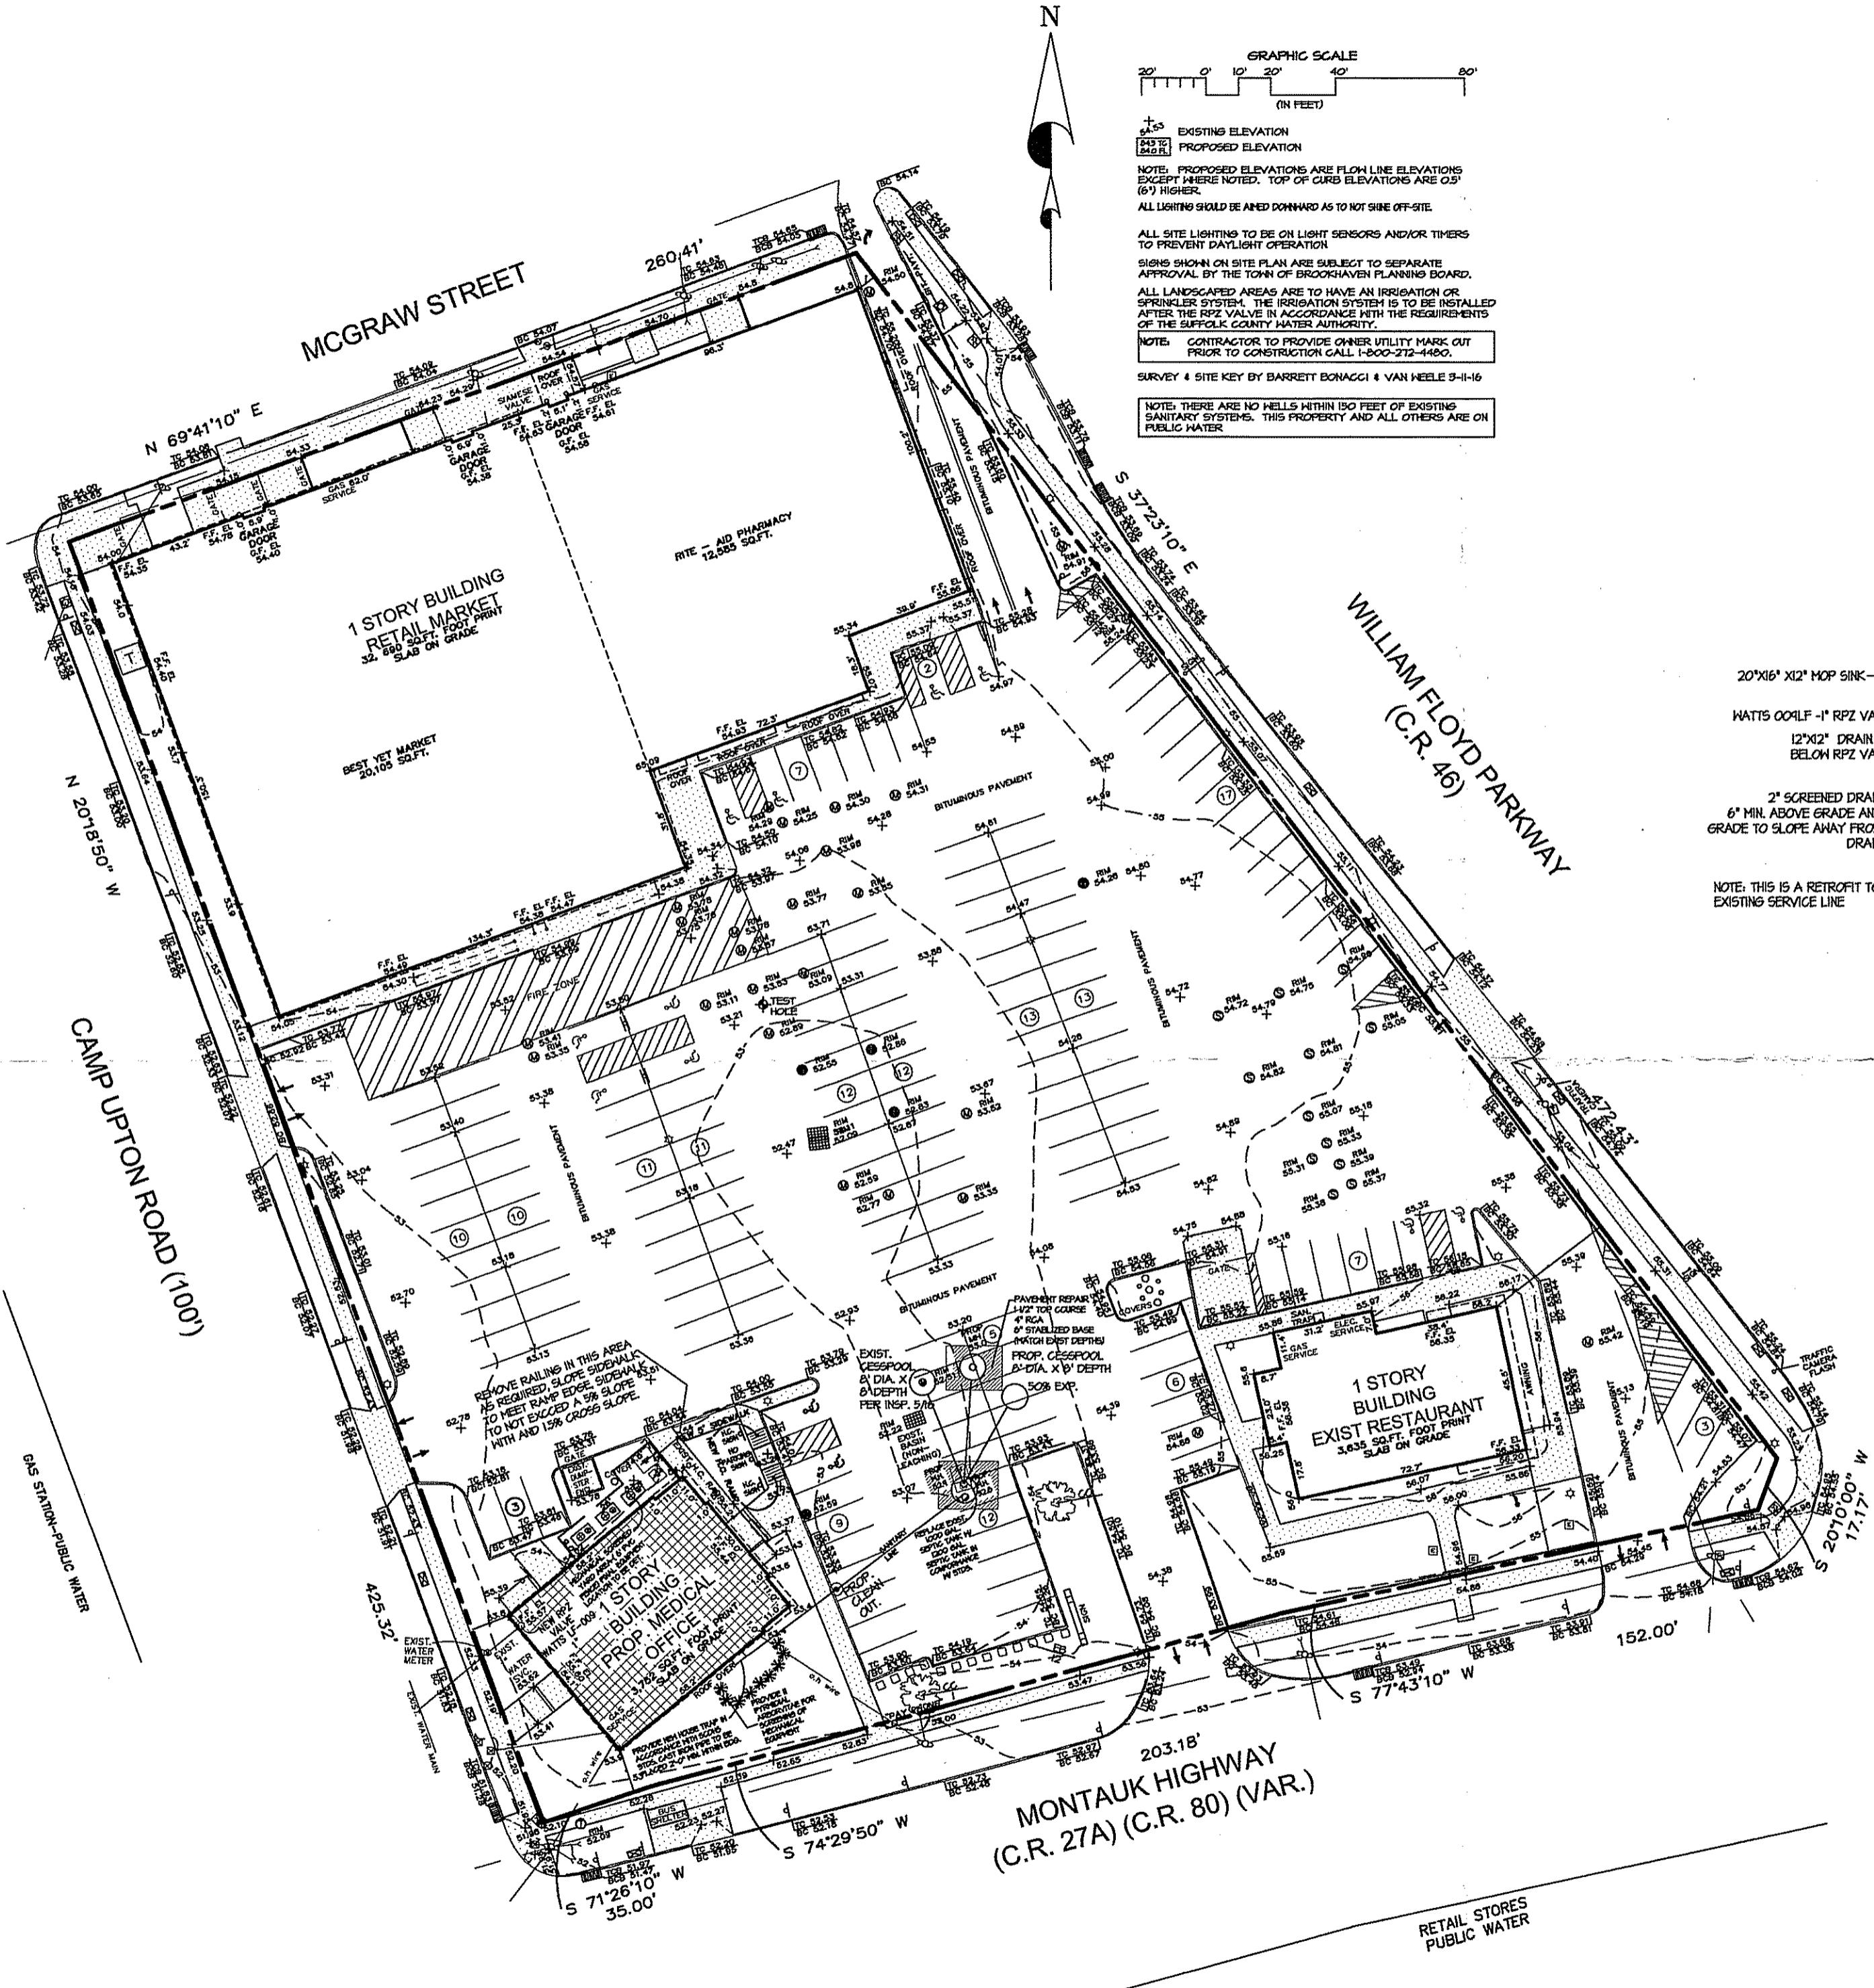


**SITE PLAN**

SCALE 1" = 40'

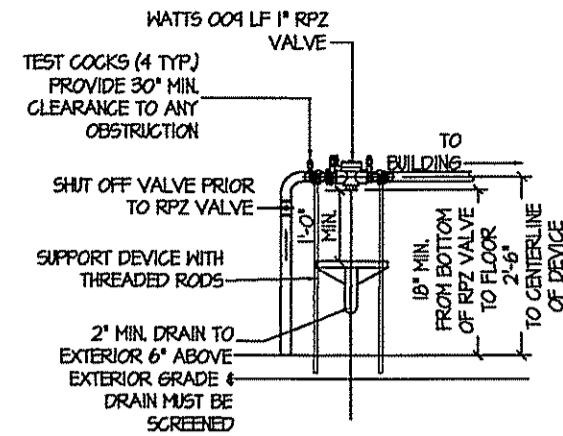

## RPZ VALVE FRONT VIEW

**NOT TO SCALE**

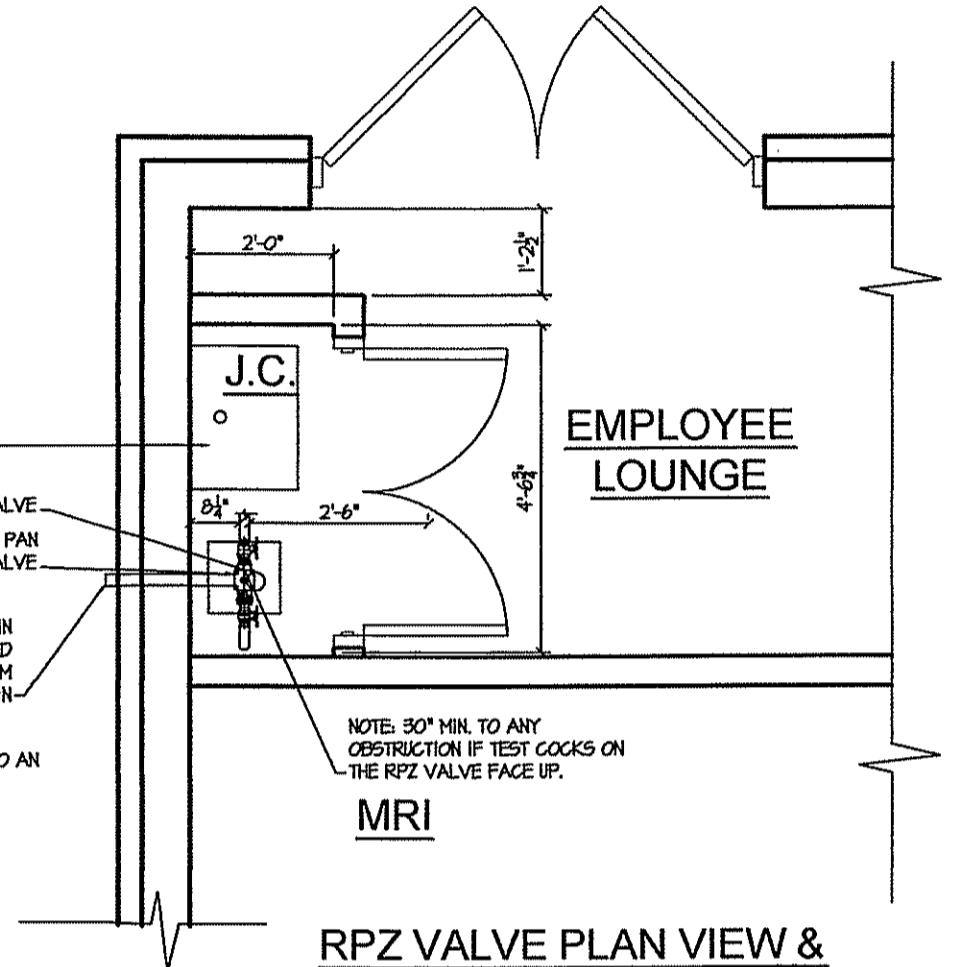


## RPZ VALVE PLAN VIEW & LOCATION

NOT TO SCALE

RPZ VALVE NOTES.

1. THIS DEVICE MUST BE PROTECTED AGAINST FREEZING.
2. TEST COCKS MUST BE POSITIONED TO FACILITATE TESTING (30" MINIMUM CLEARANCE).
3. ALL CONNECTIONS T'S, HOSE BIBS, IRRIGATION ETC. MUST BE INSTALLED AFTER (DOWNSTREAM) OF DEVICE.
4. DRAINS CANNOT BE SUBJECT TO FLOODING AND MUST BE SCREENED.
5. DESTINATION OF DRAINAGE MUST BE SHOWN.
6. PROPER MAINTENANCE MUST BE PERFORMED.
7. DEVICE MUST HAVE USC FOUNDATION FOR CROSS CONNECTION CONTROL APPROVAL.
8. DEVICE MUST BE ADEQUATELY SUPPORTED TO PREVENT LATERAL MOVEMENT. DEVICES 2" OR LARGER MUST BE SUPPORTED TO THE FLOOR.
9. SUPPORTS MUST BE PLACED WHERE THEY WILL NOT OBSTRUCT THE FUNCTION OR ACCESS TO RELIEF VALVE.
10. A SEPARATE SHUT OFF VALVE IS REQUIRED UPSTREAM OF THE ASSEMBLY.
11. ADEQUATE LIGHTING MUST BE PROVIDED.
12. DEVICE MAY NOT BE INSTALLED HIGHER THAN 5' ABOVE THE FLOOR OR A FIXED PLATFORM IS REQUIRED.
13. WHERE THE DISTANCE BETWEEN THE WATER METER AND DEVICE IS GREATER THAN 10' ALL EXPOSED PIPING MUST BE LABELED EVERY 5' DISPLAYING THE WORDS "FEED TO BACKFLOW PREVENTER DO NOT TAP"
14. ENCLOSURE TO BE N.Y. DESIGNATION.
15. ALL RPZ VALVE DEVICES SHALL BE LEAD FREE

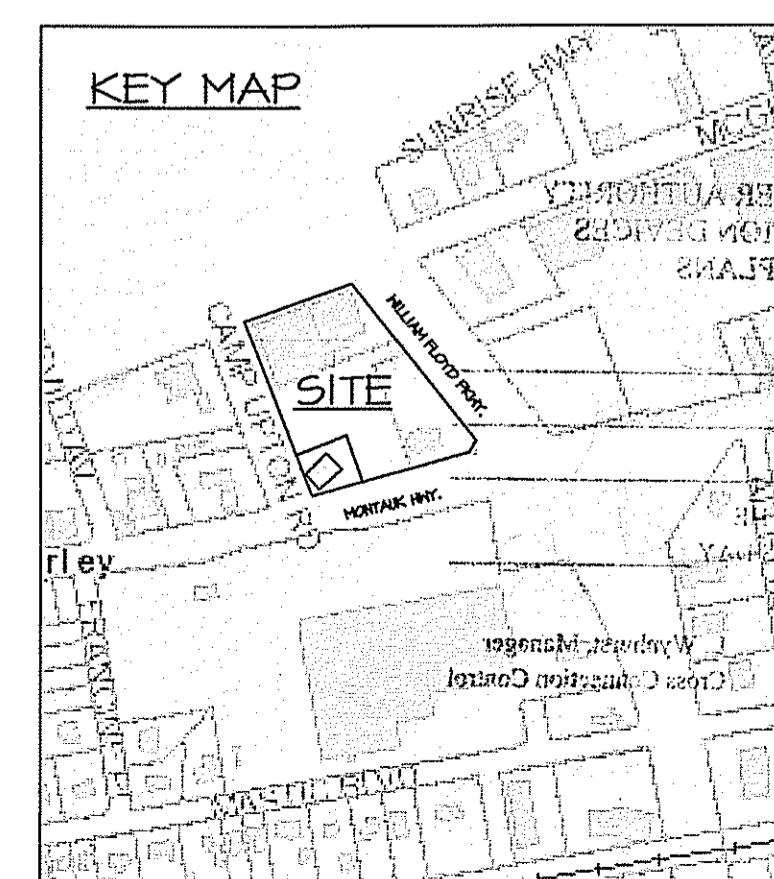

Project Name and Address  
**ZWANGER-PESIRI  
RADIOLOGY RPZ VALVE**

WYDANIA NARODOWE

801 MONTAUK HIGHWAY

D. SHIRLEY ANY

## TOWN OF BROOKHAVEN

THESE PLANS FOR

SEARCHED NO. 300-85043

U.S.P.M. NO. 200 000 42

2016-0100 DE 7025113 1556

RECORDED BY PHILIPS 4400

DEC. 2016

11. *What is the name of the author of the book?*

AS NOTED

NO NOV 2000

1. *What is the relationship between the two concepts of the "self" in the two cultures?*

RPZ-1