


REFLECTED CEILING PLAN KEY NOTES

- ① 'SAND' HATCHING INDICATES NEW CEILING GRID, EXTENDED FROM ADJACENT AREA AS SHOWN.
- ② EXTEND 4'-0" GYPSUMBOARD CEILING, AS SHOWN.
- ③ PATCH IN CEILING GRID AT DEMO'D PARTITION (INDICATED WITH 'SAND' HATCHING). GRID APPEAR TO ALIGN THROUGH/MAINTAIN FULL TILES. IF NOT, THEN DEMO THE SMALLER AREA OF CEILING GRID WITHIN THE ROOM/AREA AND PROVIDE CONTINUOUS GRID WITHIN THE ROOM/AREA.
- ④ PROVIDE NEW GYPSUMBOARD CEILING AT 4'-0". PROVIDE RELOCATED DOWNLIGHT, RELOCATED (OR NEW) EXHAUST FAN THROUGH ROOF, CEILING DIFFUSER, AND 24" WALL LIGHT BAR, AT 7'-6", CENTERED OVER THE LAVATORY.

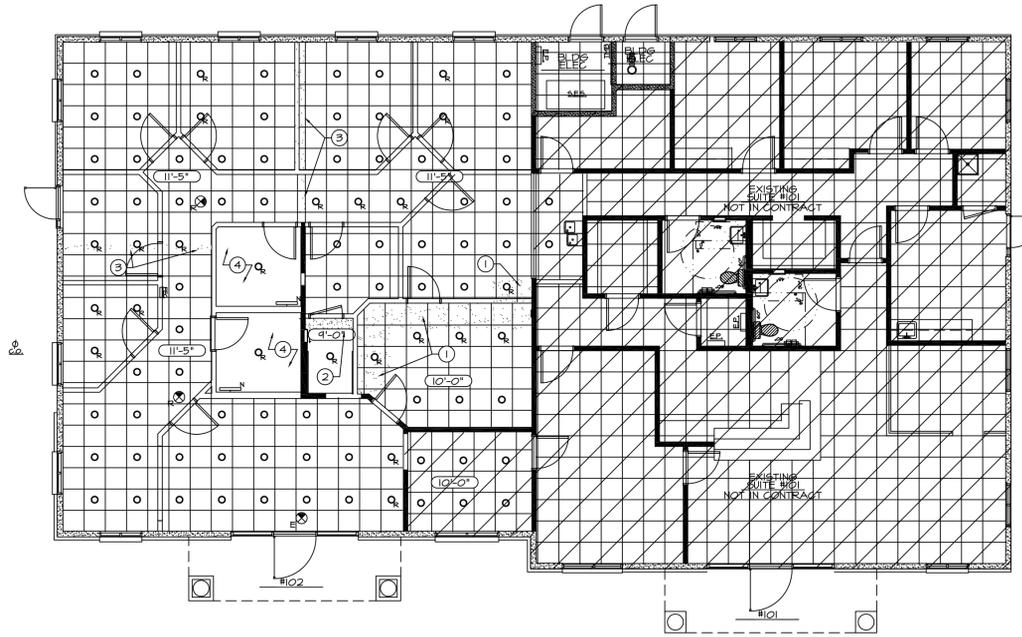

CEILING GENERAL NOTES

- NOTE: E' DESIGNATES EXISTING TO REMAIN.
 R' DESIGNATES RELOCATED POSITION
 N' DESIGNATES NEW
 D' DESIGNATES DEMO
- NOTE: ANY UNDESIGNATED ITEMS ARE EXISTING.

NOTE: SUSPENDED CEILING SHOWN ARE EXISTING: 2' X 2' WHITE 3" GRID, ARMSTRONG 'PRELUDE', REPLACE DAMAGED GRID AND AT DEMO AS REQUIRED. EXISTING HEIGHTS AS NOTED.

NOTE: ACOUSTICAL CEILING TILES ARE EXISTING: 2' X 2' REGULAR EDGE, WHITE TILES; ARMSTRONG 'DUNE' - VERIFY. DISCARD ANY DAMAGED, STAINED, CHIPPED, ETC. PROVIDE NEW TILES AS NEEDED. TILES SHALL BE CONSISTENT IN ANY GIVEN ROOM OR AREA - EITHER ALL NEW OR ALL EXISTING/RELOCATED.

NOTE: CEILING TILES HAVE 4" FIBERGLASS BATTS LAID OVER THE TILES. REPLACE ANY MISSING OR DAMAGED BATTS AND MAINTAIN CONTINUOUS INSULATION OVER THE ENTIRE CEILING.

NOTE: EXISTING HVAC DEVICES ARE 2' X 2' WHITE 3-BLADE CEILING DIFFUSERS AND RETURN AIR GRILLES. RELOCATE DEVICES PER MECHANICAL PLANS. RELOCATE AS NEEDED, AND ADD DEVICES AS REQUIRED, TO MATCH EXISTING.

NOTE: EXISTING LIGHTS THROUGHOUT ARE LED DOWNLIGHTS. RELOCATE AS SHOWN. EXISTING EXIT SIGNS ARE EDGE LIGHT / RED LETTERS WITH SATIN ALUMINUM TOP FRAMES. RELOCATE AND ADD, TO MATCH EXISTING, AS REQUIRED.

NOTE: SPRINKLER HEADS ARE SEMI-RECESSED CHROME HEADS AND ESCUTCHEONS. RELOCATE AND ADD SPRINKLER HEADS AS REQUIRED, PER NEW FLOOR PLAN, UNDER SEPARATE PERMIT.


NOTE: RELOCATE AND ADD FIRE ALARM DEVICES AS REQUIRED PER NEW FLOOR PLAN, UNDER SEPARATE PERMIT.

REFLECTED CEILING PLAN

1/8" = 1'-0"

DEMOLITION CEILING PLAN KEY NOTES


- NOTE: MECHANICAL CEILING DIFFUSERS AND RETURN AIR GRILLES ARE EXISTING LOCATIONS, AND ARE SHOWN FOR REFERENCE ONLY. SEE MECHANICAL PLANS FOR NEW HVAC LAYOUT.
- NOTE: SPRINKLER HEAD SHOWN ARE EXISTING LOCATIONS, AND ARE SHOWN FOR REFERENCE ONLY.
- NOTE: FIRE ALARM DEVICES SHOWN ARE EXISTING LOCATION, AND ARE SHOWN FOR REFERENCE ONLY.
- ① DASHED LINES INDICATE EXISTING CEILING GRID TO BE DEMO'D. STOCKPILE LIGHTS / HVAC / SPRINKLERS / FIRE ALARM DEVICES FOR REUSE/RELOCATION.
 - ② DEMO EXISTING 4" GYPSUMBOARD CEILING. STOCKPILE EXHAUST FAN AND CEILING DIFFUSER FOR REUSE/RELOCATION.

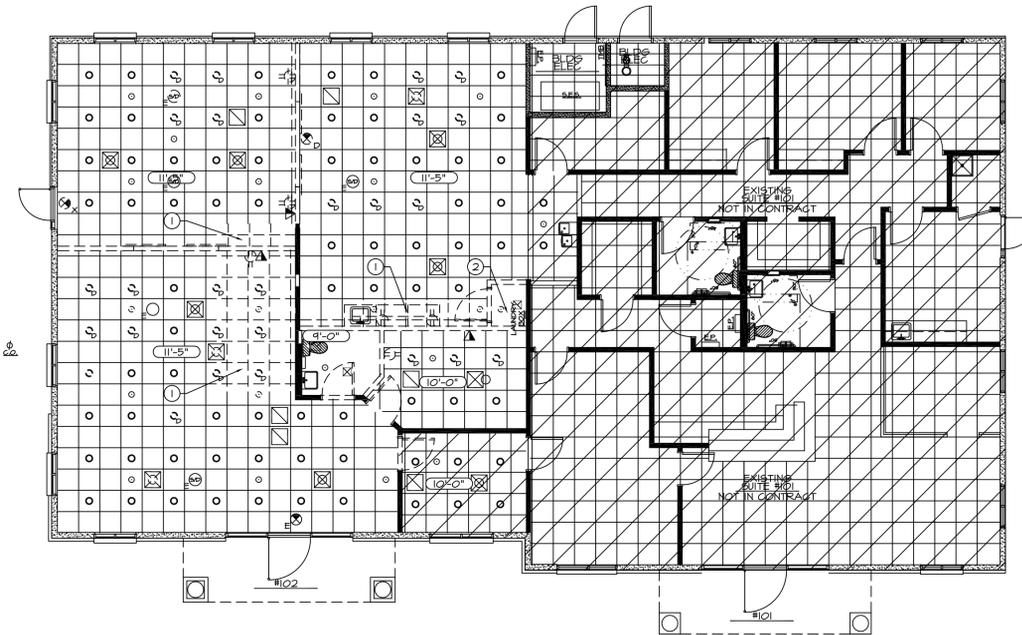

DEMOLITION CEILING PLAN

1/8" = 1'-0"

SCOPE OF WORK

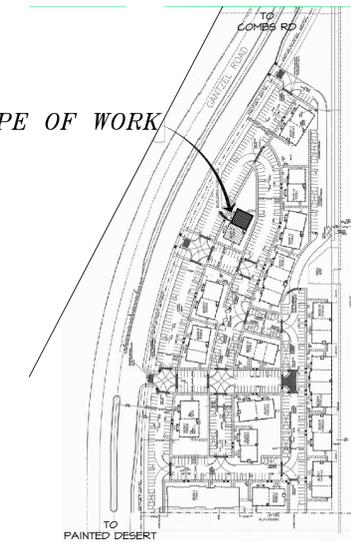

KEY PLAN

NTS

PINAL PROFESSIONAL VILLAGE

BLGD 16: 36457 N. GANTZEL RD. SAN TAN VALLEY, AZ 85140

2nd CHANCE TREATMENT CENTER

REFLECTED CEILING PLAN & DEMOLITION CLG PLAN

PROJECT:

PROJECT NO: 2125.01
 DATE: 10-22-2021
 REVISED:

DRAWN BY: JT

SHEET

A2.0

OF



JIGGES DESIGN INTERIORS LLC

ARCHITECT REVIEW DISCLAIMER
 J. WIGGINS ARCHITECT, P.C. HAS REVIEWED THIS PROJECT FOR COMPLIANCE WITH THE ARCHITECTURAL BOARD OF THE STATE OF ARIZONA. THIS REVIEW IS LIMITED TO THE ARCHITECTURAL ASPECTS OF THE PROJECT AND DOES NOT CONSTITUTE A GUARANTEE OF THE ACCURACY OF THE INFORMATION PROVIDED HEREON.

PHOENIX, AZ 85032 PH: (602) 228-6871 FAX: (602) 595-2925