


**MECHANICAL FLOOR PLAN**  
1/8" = 1'-0"

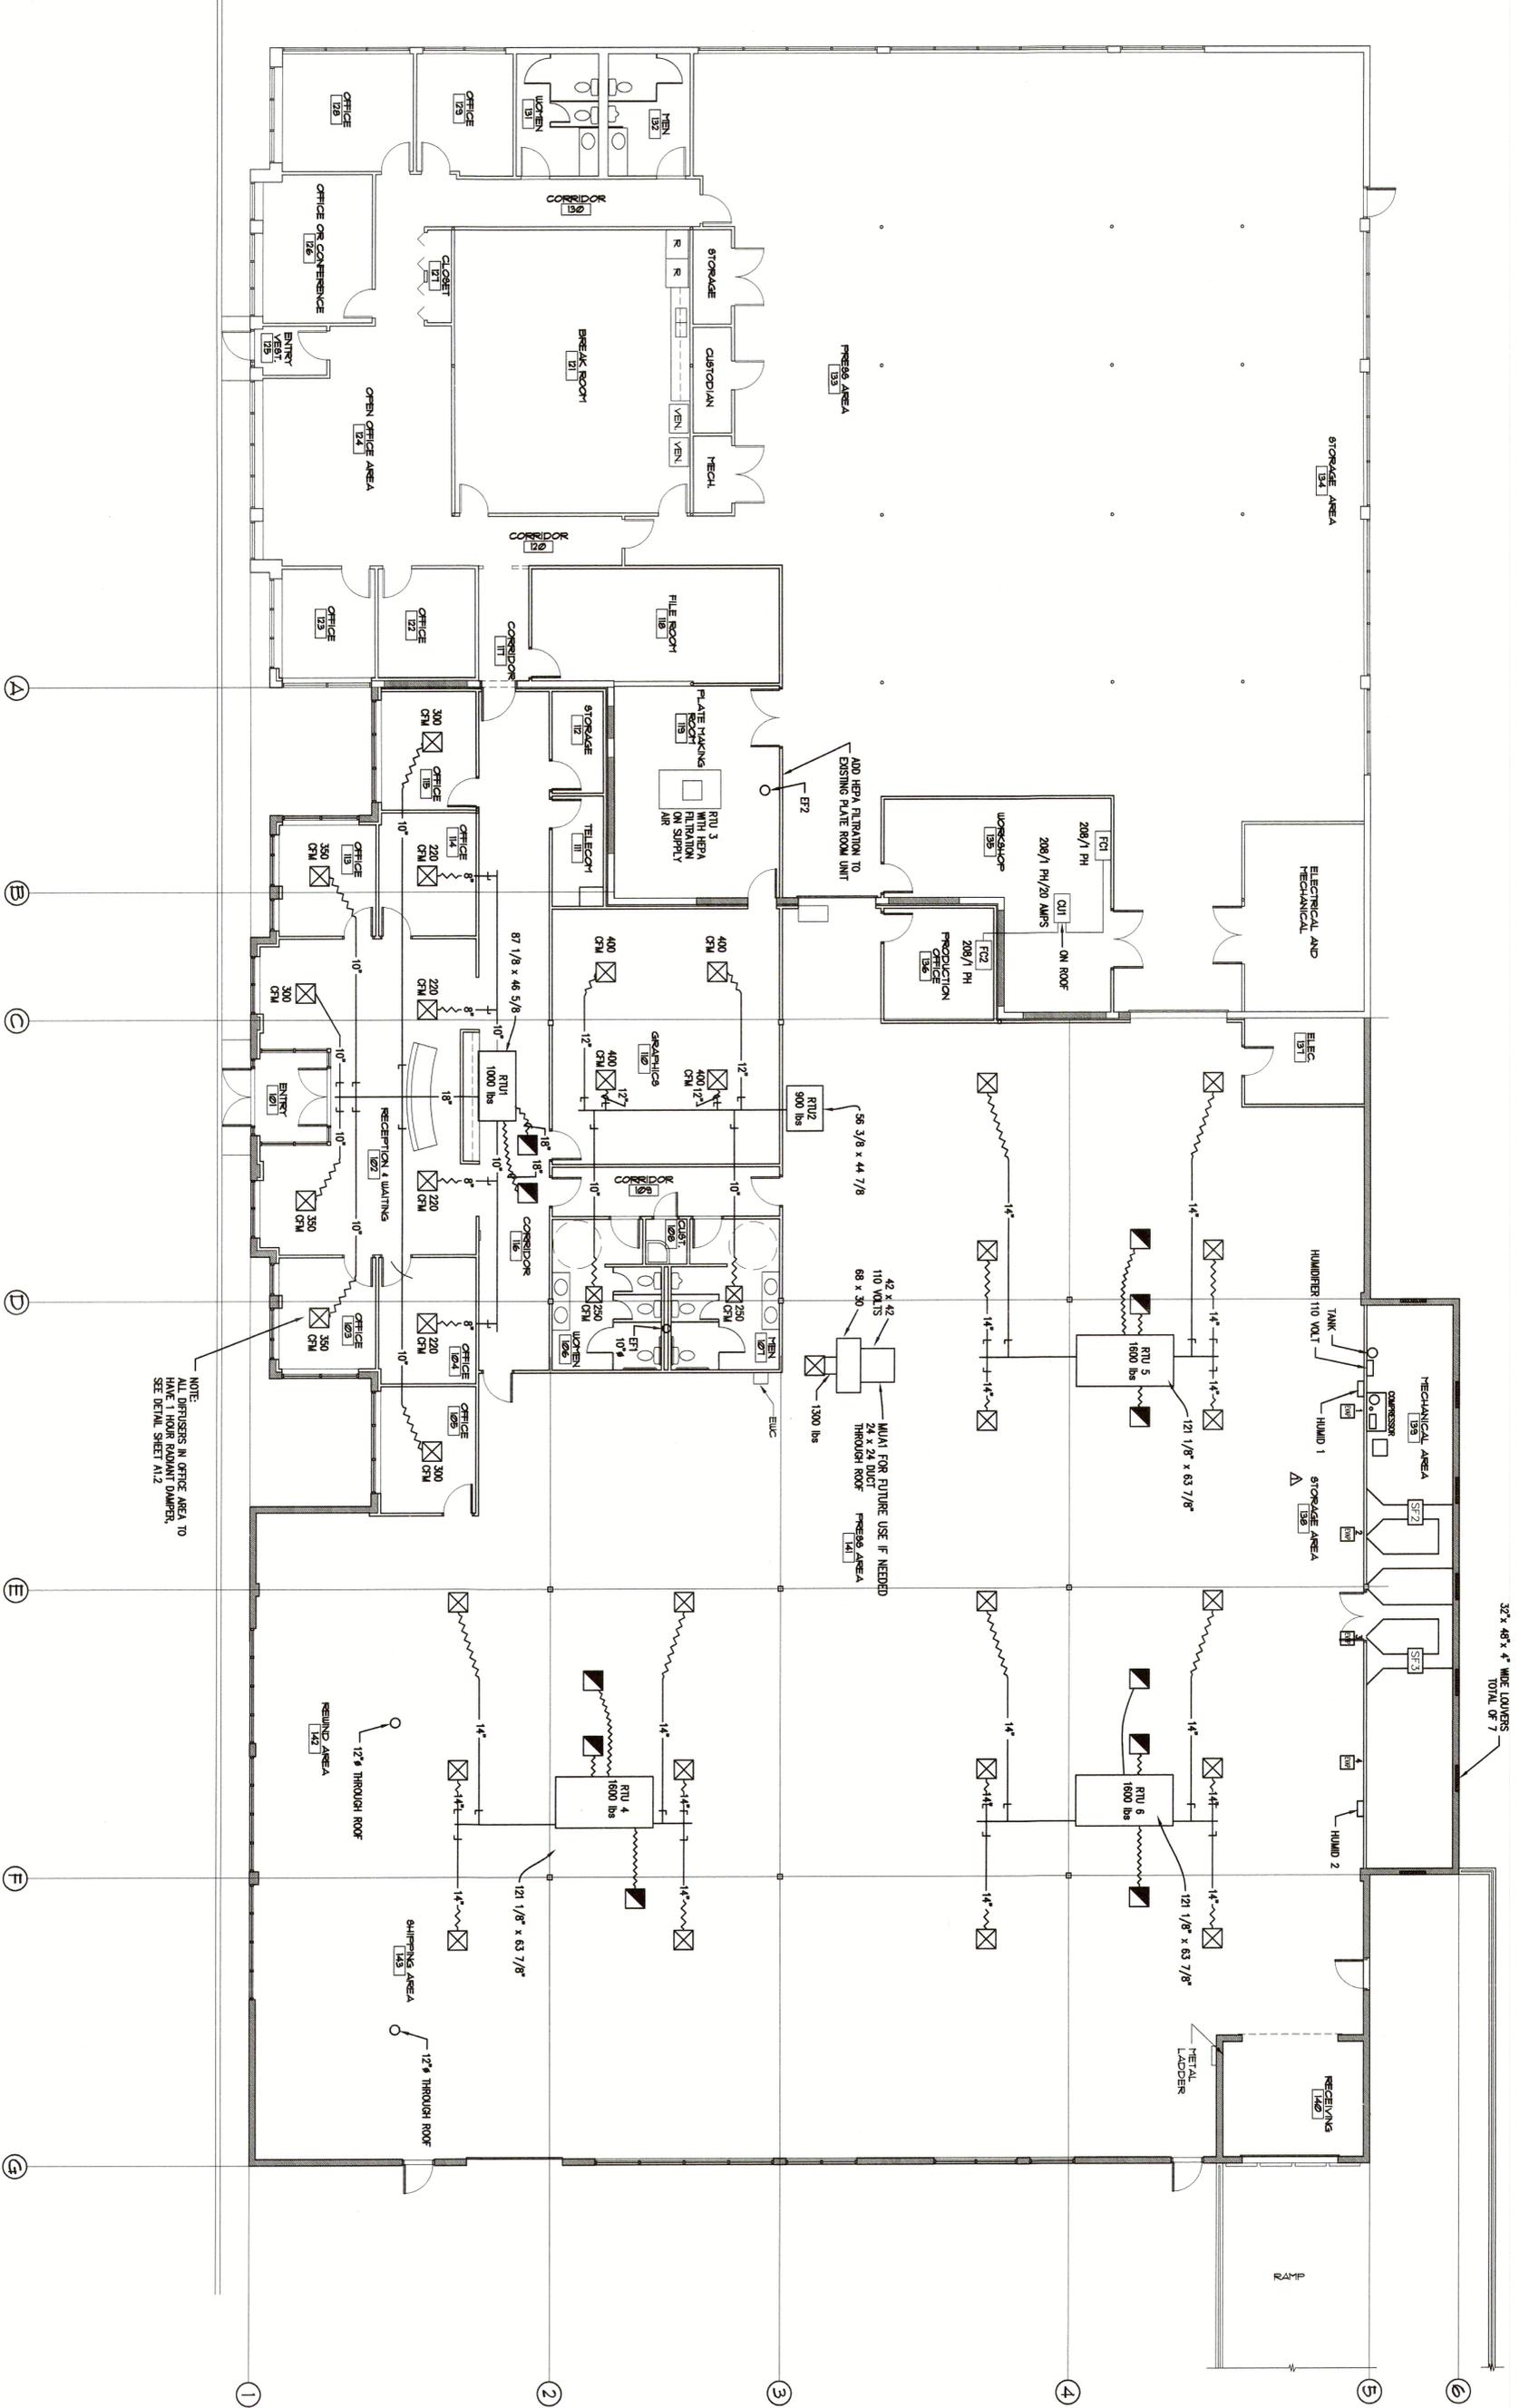

NOTE:  
ALL DIFFUSERS IN OFFICE AREA TO  
HAVE 1 HOUR RADIANT DAMPERS.  
SEE DETAIL SHEET A12.

32' x 48' x 4" WIRE LOUISERS  
TOTAL OF 7

Revisions
1 APRIL 26/03
2
3

Drawn by: KTC  
Date: SEPTEMBER 2002  
Checked by: KG 4 RS  
Job No: 2205

**FLEX TECH**  
ADDITION AND REMODEL  
OREM BUSINESS PARK  
1275 SOUTH 1600 WEST OREM UTAH

**RICHARD GARDNER & ASSOCIATES, INC.**  
ARCHITECTURE · PLANNING · DESIGN  
Evergreen Square • 875 South Orem Boulevard Suite #2 Orem Utah, 84058 • Phone 801 765 1212 • Fax 801 765 1213

Sheet No. **M1**  
REVISED