


INSTALL 2 IN METER AND REGULATOR SYSTEM PIPE
ALSO ADD 4 OUNCE REGULATORS ON ALL GAS APPLIANCES

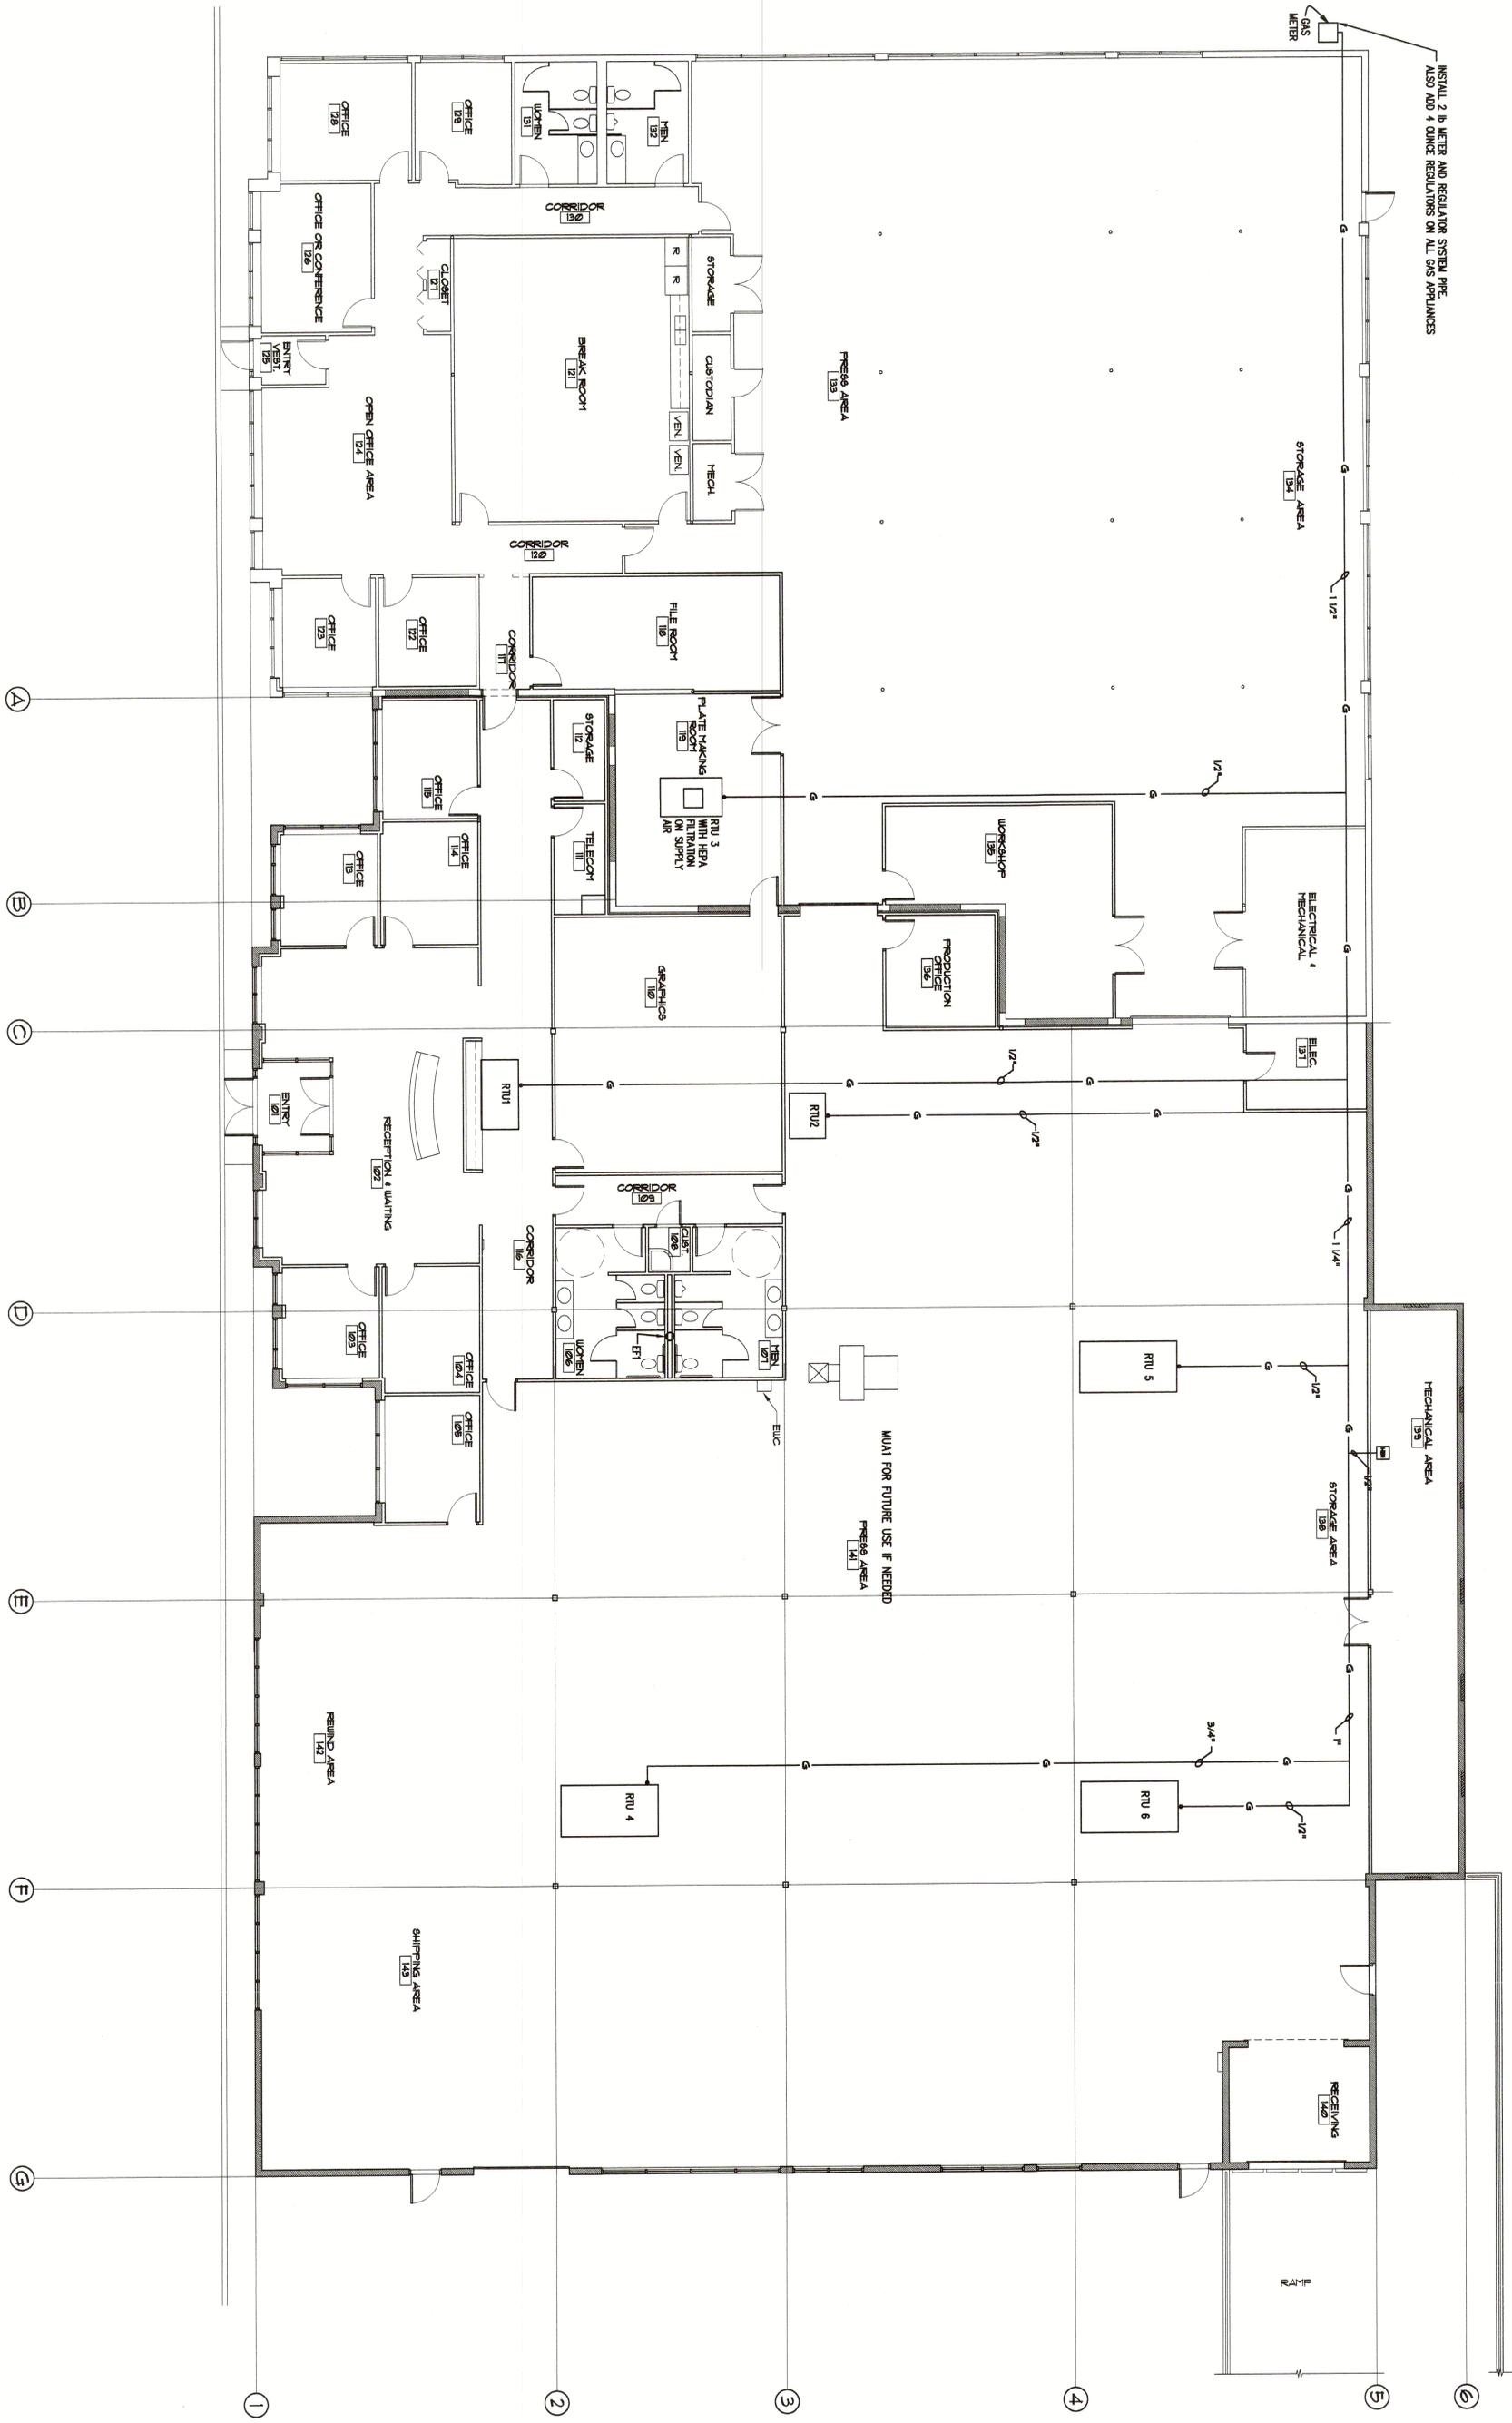

GAS PIPING PLAN



1/8" = 1'-0"

Revisions

FLEX TECH
 ADDITION AND REMODEL
 OREM BUSINESS PARK
 1275 SOUTH 1600 WEST OREM UTAH



RICHARD GARDNER & ASSOCIATES, INC.
 ARCHITECTURE . PLANNING . DESIGN
 Evergreen Square • 875 South Orem Boulevard Suite #2 Orem Utah, 84058 • Phone 801 765 1212 • Fax 801 765 1213

Sheet No. **P1.4**
 Drawn by: KYC
 Date: SEPTEMBER 2002
 Checked by: KG & NS
 Job No: 0205