


CERTIFIED BOUNDARY SURVEY

CLIENT:

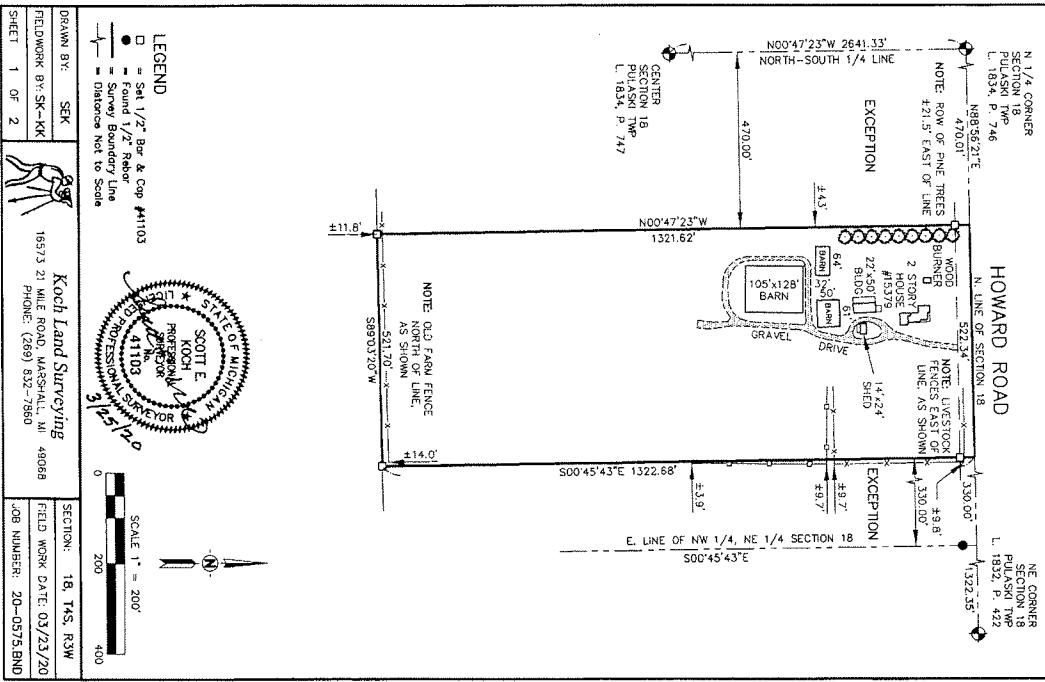

CERTIFIED BOUNDARY SURVEY

CLIENT:

CERTIFICATE OF SURVEY

I hereby certify, only to the client named herein, that I have surveyed a parcel of land described as:

Legal Description (per ATA National Title Group, LLC 38-13580451-ELN, as provided):
The Northwest 1/4 of the Northwest 1/4 of Section 18, Town 4 South, Range 3 West, Puskin Township, Jackson County, Michigan. EXCEPTING, therefrom the West 470 feet and EXCEPT, the East 330 feet.

Tax ID No. 000-16-18-201-001-02
Commonly known as: 15379 Howard Road, Hanover, MI 49241

and that I have found or set, as noted herein, permanent markers at all corners and angle points of the boundary of the parcel shown herein.

This survey complies with the requirements of Public Act 132 of 1970, MCL 54.213. The relative precision of the corners identified for this survey, and as shown on the map are within the limits accepted by the practice of professional surveying.

卷之三

Sheet 9/10 3/25/24
Scott E. Koch Date
Professional Surveyor No. 41100

A circular seal for a Michigan professional surveyor. The outer ring contains the text "STATE OF MICHIGAN" at the top and "PROFESSIONAL SURVEYOR" at the bottom. The inner circle contains "LICENSING BOARD" at the top and "41103" at the bottom. The name "SCOTT E. KOCH" is in the center, with "PROFESSIONAL SURVEYOR" written vertically to the left of the name and "No. 41103" written vertically to the right of the name.

THE CHINESE IN AMERICA 11

Nearest Church: Pulaski Free Methodist Church
9975 Miller Road
Honover, MI 49241
3.0 Miles

Nearest School: Concord Middle School
405 S. Main Street
Concord, MI 49237
4.0 Miles

Nearest Licensed Daycare: KU Kingdom Childcare 10855 Dew Road Hanover, MI 49241 6.2 Miles

DRAWN BY:	SEK		Koch Land Surveying
FIELDWORK BY:	SK-WK		1857.5 21 MILE ROAD, MARSHALL, MI 49068
SHEET 2 OF 2		1857.5 21 MILE ROAD, MARSHALL, MI 49068	SECTION: 18, T-8, R-8 FIELD WORK DATE: 03/23/2018 PHONE: (269) 632-2860 JOB NUMBER: 20-0575.BNC

CERTIFIED BOUNDARY SURVEY

CLIENT:

HOWARD ROAD

N. LINE OF SECTION 18

N. 1/4 CORNER
SECTION 18
PIASNA Twp
L. 1834, P. 746
N085521.21'E
470.01'

N0047'23"W 2641.33'
NORTH-SOUTH 1/4 LINE

NOTE: ROW OF PINE TREES
421.5' EAST OF LINE

470.00'

N. LINE OF SECTION 18

N0047'23"W 1321.62'
N0047'23"W 1322.68'

NOTE: LIVESTOCK
FENCE, EAST OF
LINE, AS SHOWN
330.00'

±11.6' ±14.0' ±3.9'

±4.5' ±4.5' ±9.7'

±21.0' ±21.0' ±3.9'

S89.03' 20' W

E. LINE OF NW 1/4, NE 1/4 SECTION 18
S0045'43"E 1322.68'

S0045'43"E

SECTION: 18, Twp. RSW
FIELD WORK DATE: 03/23/20
JOB NUMBER: 20-0575.BND

DRAWN BY: **SEK**

FIELDWORK BY: **SK-KK**

SHEET 1 OF 2

LEGEND

- = Set 1/2" Bar & Cap #41103
- = Found 1/2" Rebar
- = Survey Boundary Line
- = Distances Not to Scale

STATE OF MICHIGAN
SCOTT E. KOCH
PROFESSIONAL SURVEYOR
#41103
PROFESSIONAL SURVEYOR
#41103
Koch Land Surveying
16573 21 MILE ROAD, MARSHALL, MI 49068
PHONE: (269) 832-7860

SCALE: 1" = 200'

0 200 400

CERTIFIED BOUNDARY SURVEY

		15379 Howard Rd. Hanover, MI 49241		VIGNE	
				GIOVANNI LAVIGNE REGISTERED ARCHITECT	
				14100 WOODWARD AVE. SUITE 355 EAST BLOOMFIELD HILLS, MI 48301 866.242.4525	
				PROJECT	
				DRAWING TITLE	
				SURVEY	
				DRAWING NO.	
				SHEET NO.	
				AS1.1	
				P.O. # 20-0326	
				DRAWN: <u>AA</u> CHECKED: <u>OK</u>	

TO ACCOMMODATE NEW LIGHT SWITCHES
RELOCATE EXISTING CEILING FAN, CONFIRM LOCATION WITH OWNER

ELECTRICAL EQUIPMENT SCHEDULE

EXIT SIGN WITH EMERGENCY LIGHT

EMERGENCY LIGHT

EXIT SIGN

CUSTOM 48" LED GROW LIGHT

48" LED STRIPLIGHT, DIMMABLE

RECESSED CAN LIGHT

OSCILLATING FAN

CEILING FAN

WALL SWITCH, DIMMABLE

WALL SWITCH - EXISTING

POWER SCHEDULE

DUPLEX OUTLET

DUPLEX OUTLET - EXISTING

DOUBLE DUPLEX OUTLET

PROJECT

VIGNE
Architects and Engineers
GIOVANNI LAVORE
15379 Howard Rd.
BLOOMFIELD HILLS, MI 48304
586.242.4525

41000 WOODWARD AVE, SUITE 350 EAST
BLOOMFIELD HILLS, MI 48304

200
REFLECTED CEILING PLAN
Scale: 1/4" = 1'-0"

1
ELECTRICAL PLAN
Scale: 1/4" = 1'-0"

2
REFLECTED CEILING PLAN
Scale: 1/4" = 1'-0"

Proj. # 20-0326
DRAWING TITLE:
B1 ELECTRIC
& REFLECTED
CEILING
PLANS
DRAWN: AA
CHECKED: GL
SHEET No.
A4.0

15379 Howard Rd.
Hanover, MI 49241