


GUARDRAIL ATTACHMENT

SCALE: 1 1/2" = 1'-0"

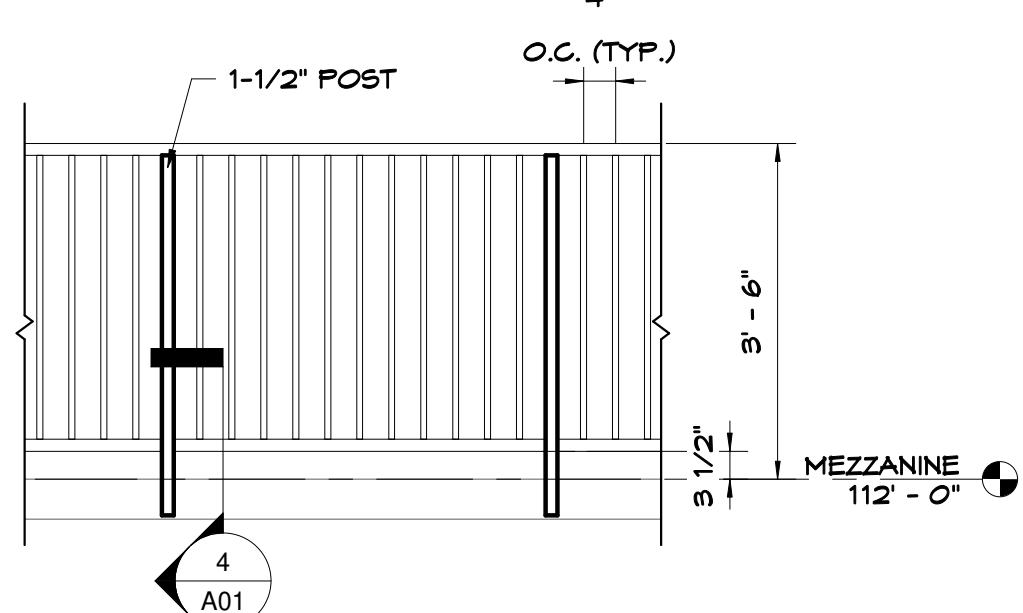

GUARDRAIL

SCALE: 1/2" = 1'-0"

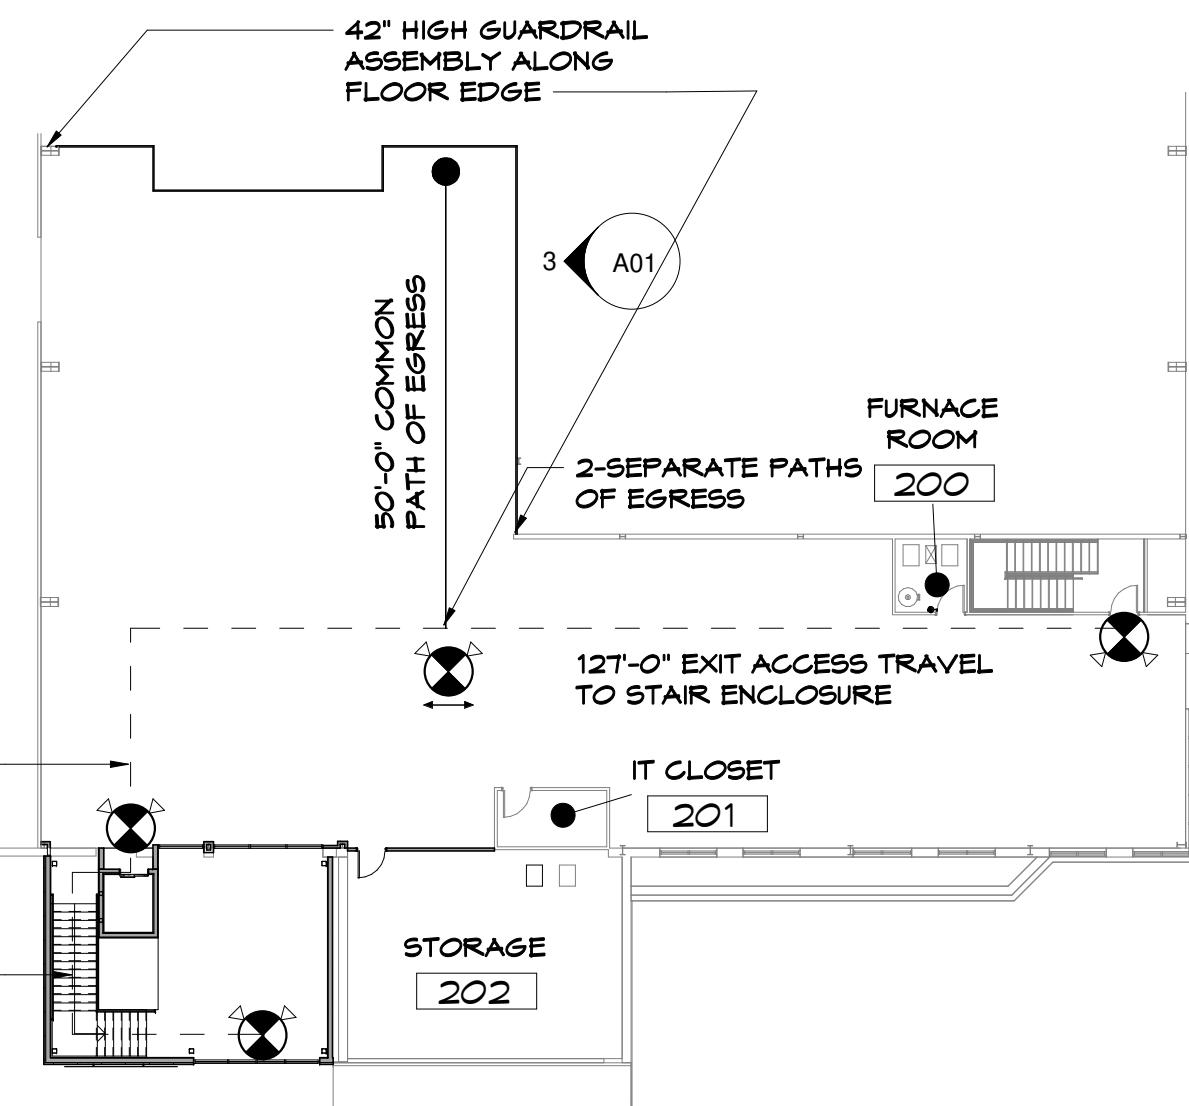


CHART 10 MEANS OF EGRESS OCCUPANT LOAD-BIG BUILDING
ADMIN AREA..... 30 OCCUPANTS (2,981 S.F. / 100 GROSS)
PLAYING COURTS AREA (BASED ON FULL USE OF 2 VOLLEYBALL COURTS)
(1) TEAM SHALL CONSIST OF 12 PLAYERS & 2 COACHES
14x2 TEAMS x 8 COURTS..... 224 OCCUPANTS
REFEREES PER COURT..... 24 OCCUPANTS
CONCESSION EMPLOYEES..... 4 OCCUPANTS
SPECTATORS.....
CONCESSION SEATING (6 PEOPLE PER TABLE; 10 TABLES)
TABLES..... 60 OCCUPANTS
BLEACHERS..... 124 OCCUPANTS

OUTBUILDING 150 - BASED ON FULL USE OF 1 BASKETBALL PLAYING COURT
(1) TEAM SHALL CONSIST OF 15 PLAYERS & 3 COACHES
16x2 TEAMS..... 36 OCCUPANTS
REFEREES..... 3 OCCUPANTS
TOTAL..... 39 OCCUPANTS

TOTAL OCCUPANT LOAD... 480 OCCUPANTS

12 PROVIDED (4 MAIN BUILDING; 3 OUT BUILDING)
EGRESS WIDTH ON FIRST FLOOR: 480 x .15 = 72"; EACH EXIT HAS 32" CLEAR WIDTH

COMMON PATH OF EGRESS TRAVEL DISTANCE DOES NOT EXCEED 75 FT.
EXIT ACCESS TRAVEL DISTANCE DOES NOT EXCEED 250 FT.

CHART 24 PLUMBING FIXTURE COUNT
480 OCCUPANTS-240 MALE AND FEMALE

- REQUIRED FIXTURE COUNTS (A-4 USE)
 - FEMALE - TOILETS; 1 PER 40. LAVATORIES; 1 PER 150
 - MALE - TOILETS; 1 PER 75 LAVATORIES; 1 PER 200
 - DRINKING FOUNTAIN - 1 PER 1,000
 - SERVICE SINK - 1

PROVIDED FIXTURES
FEMALE - 6 TOILETS (4 IN WOMENS 113 & 2 FAMILY RESTROOMS)
5 LAVATORIES (3 IN WOMENS 113 & 2 FAMILY RESTROOMS)

MENS - 2 TOILETS; 2 URINALS

3 LAVATORIES


RESTROOMS 111 & 112 ARE NOT FOR PUBLIC USE

HI-LO DRINKING FOUNTAIN PROVIDED

SERVICE SINK PROVIDED IN STORAGE 118

EXIT SIGN LEGEND

- EXIT SIGN WITH EGRESS LIGHT
- DIRECTIONAL EXIT SIGN WITH EGRESS LIGHTS

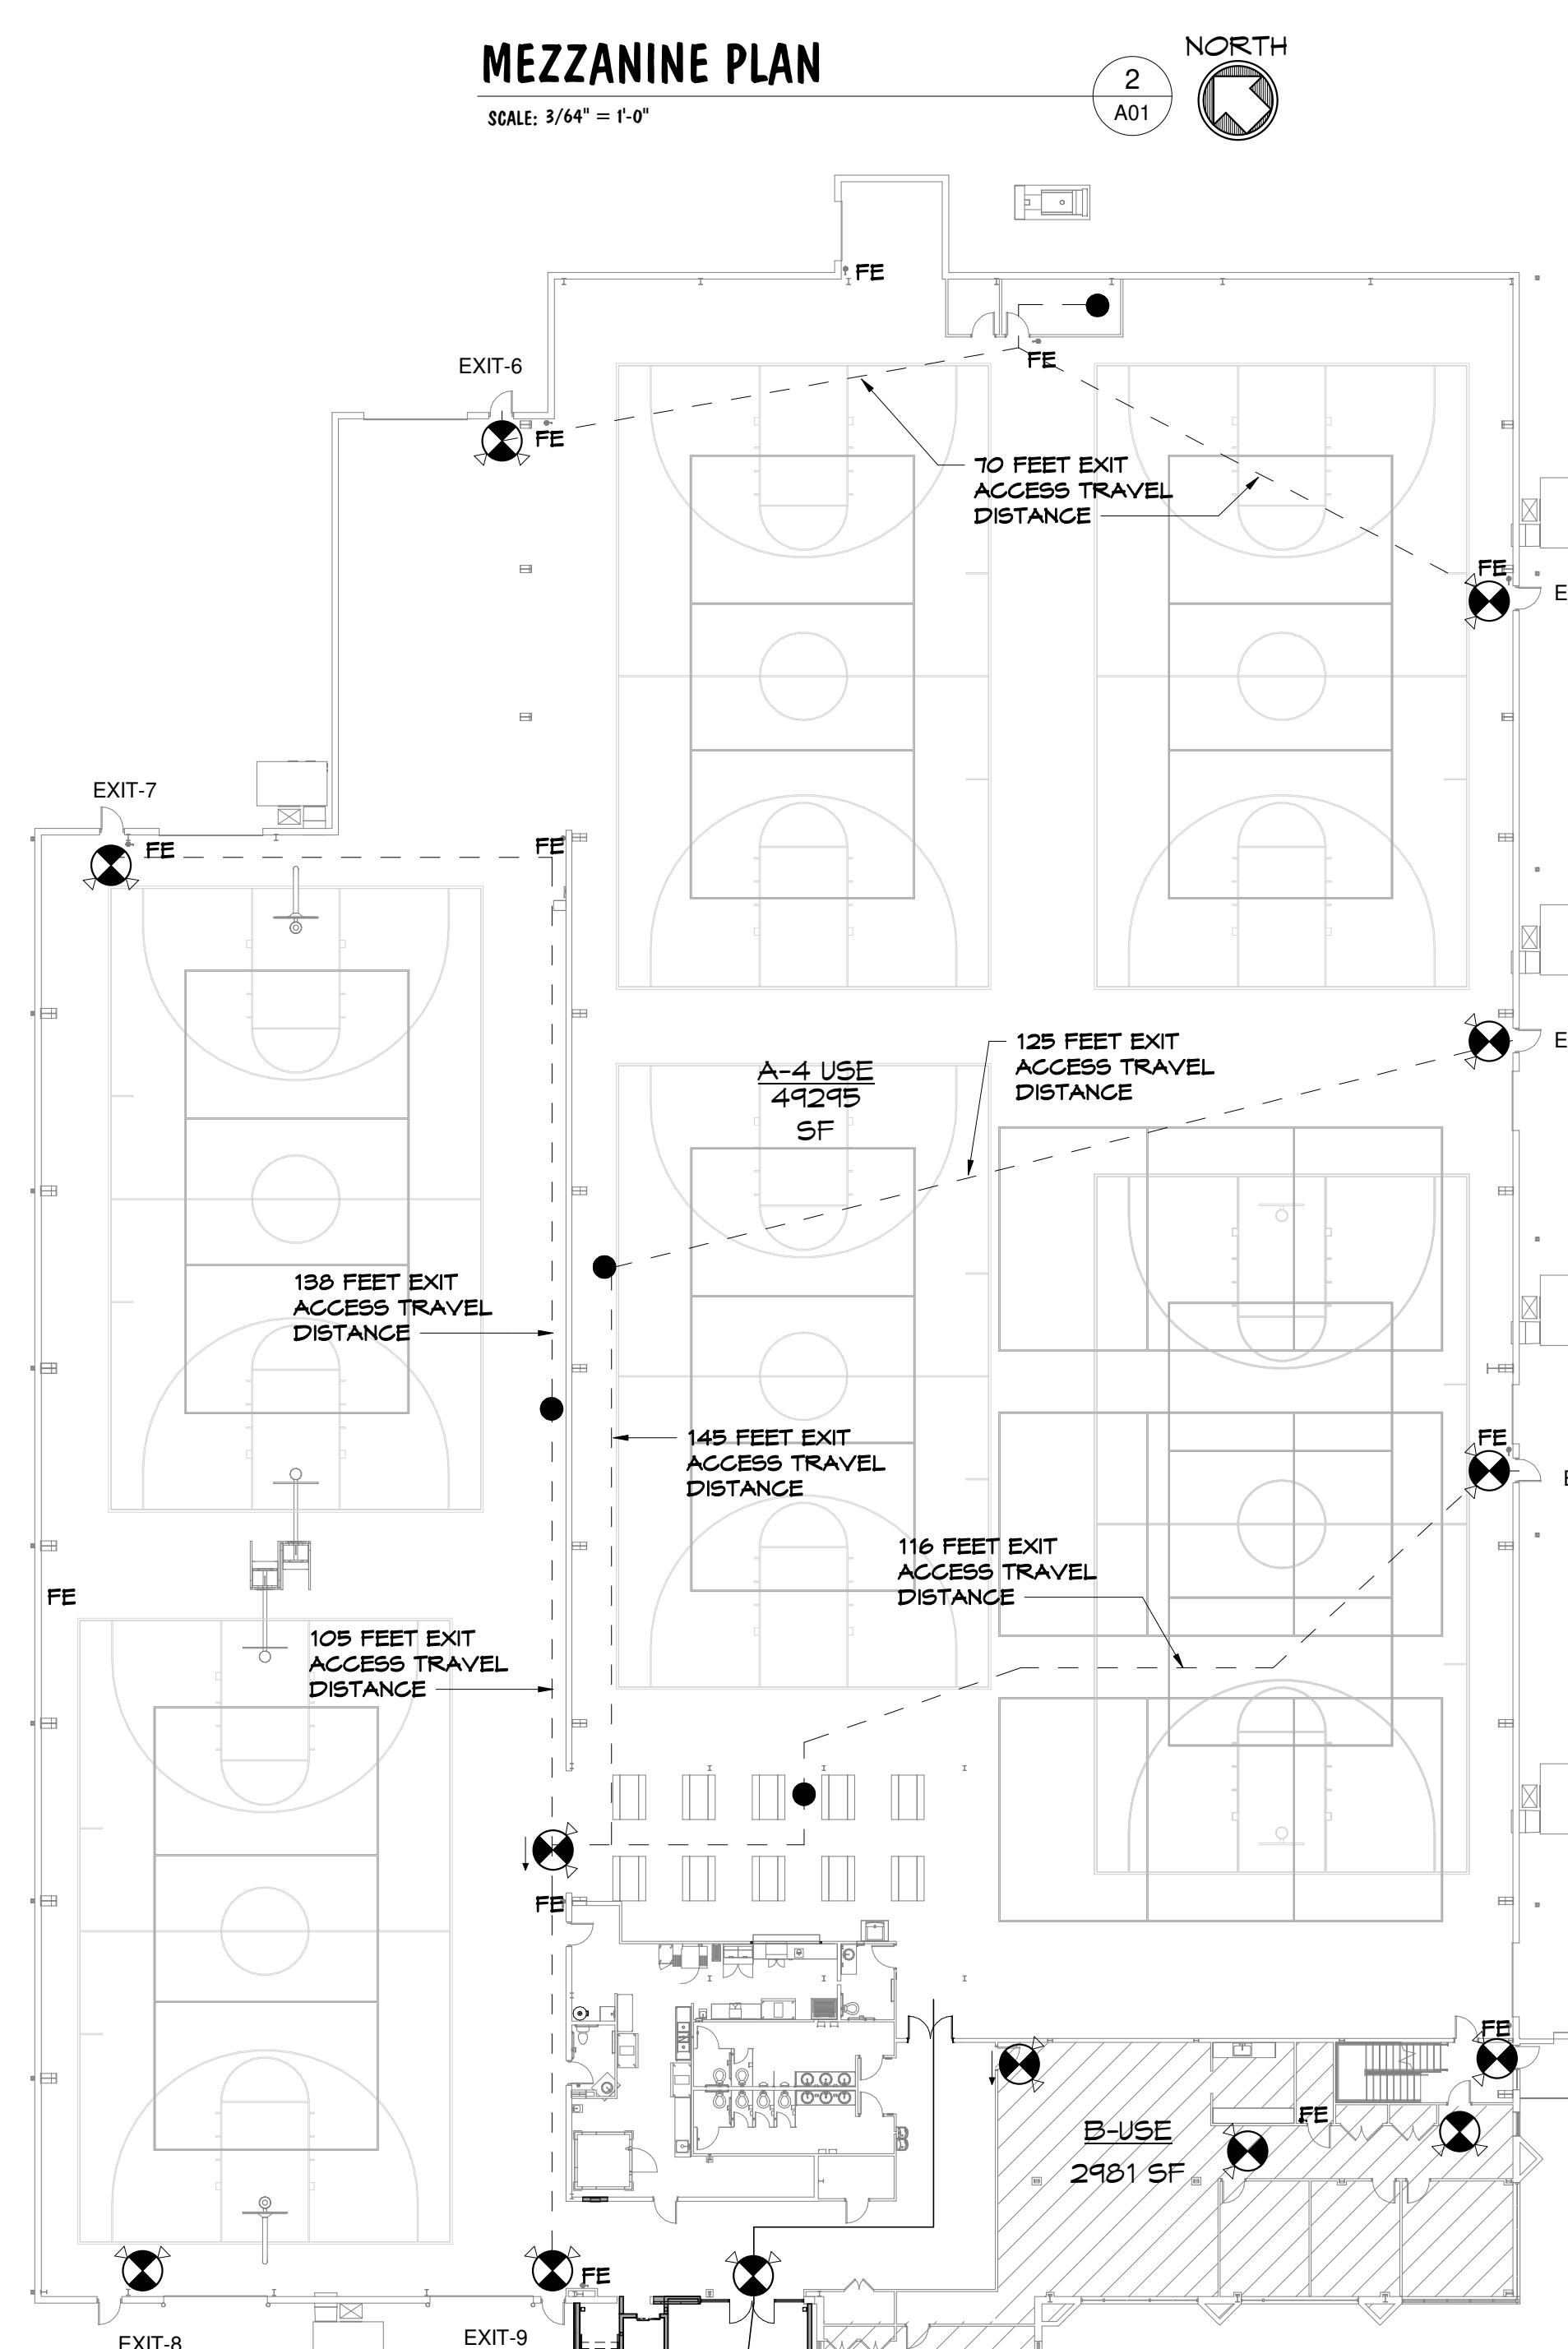


AREA LEGEND

- 2981 SF B-USE
- 8221 SF A-4 USE OUT BUILDING
- 49295 SF A-4 USE
- ADA ACCESSIBLE ROUTE

LIFE SAFETY PLAN

SCALE: 3/64" = 1'-0"

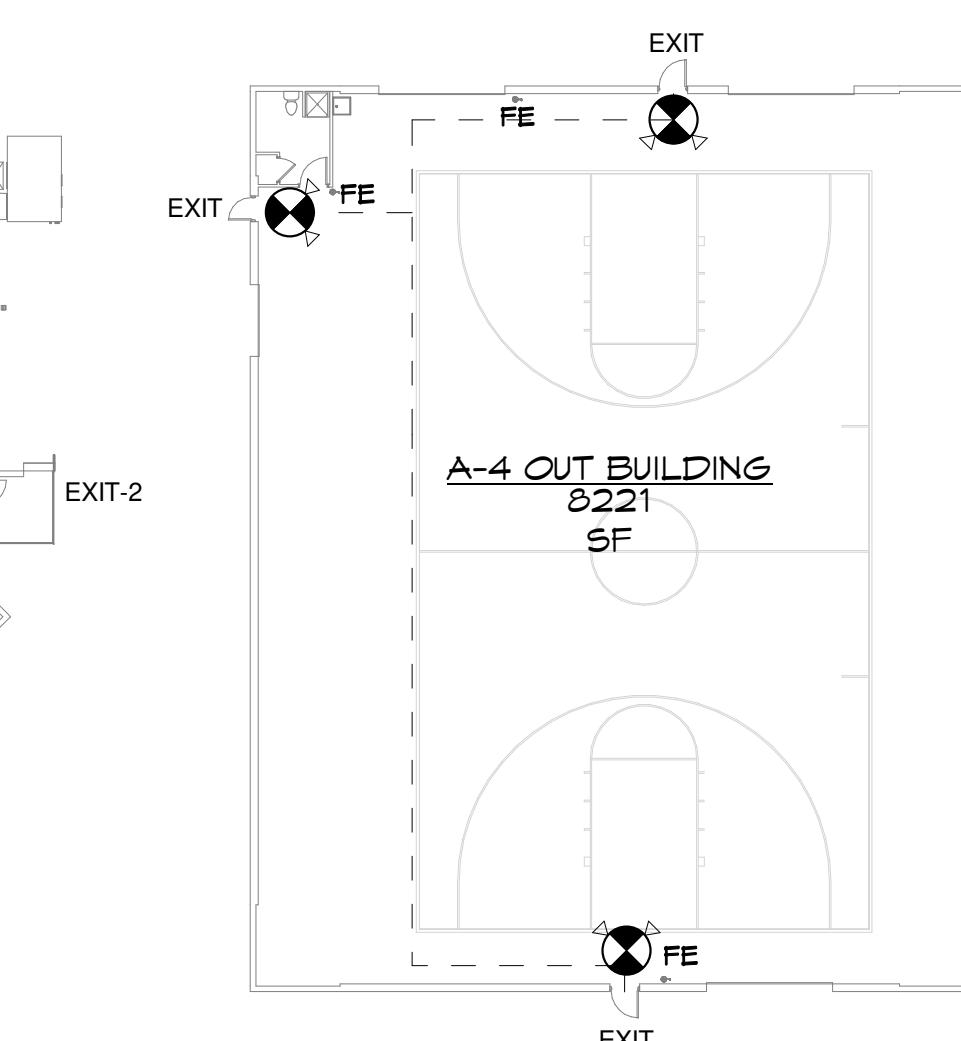

**Entry Addition for:
ELITE ATHLETICS SPORTS COMPLEX
1155 OLD STATE RTE 74
BATAVIA, OHIO 45103**

REV. DATE
1 02-01-21 FOR CONSTRUCTION

Drawn By: MJR Checked By: MDB



Date: 1-5-21 Job No: 20.062.3

A01