


ENGINEERING BY: RICHARD L. BENNETT, ARCHITECT


BENNETT & ASSOCIATES 3158 DORIS STREET CRESTVIEW, FL 32536 (850) 682-3905

STATE OF FLORIDA / LIC # 12075

SHEET NUMBER

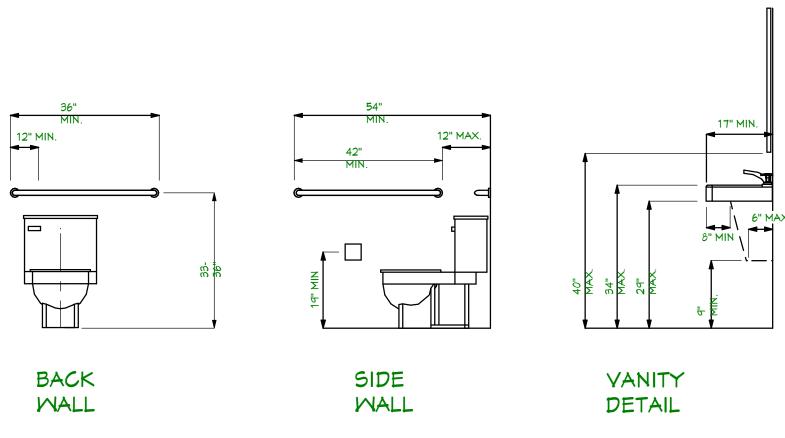


ADA RESTROOM FIXTURE DETAIL NOT TO SCALE

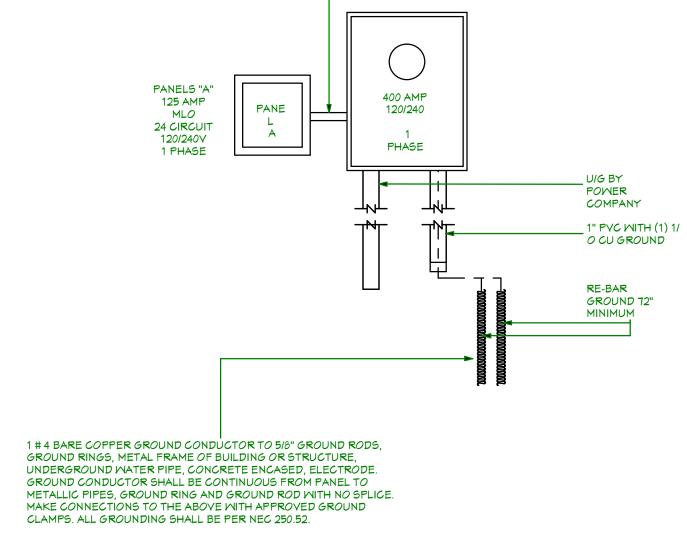

ELECTRICAL RISER PLAN NOT TO SCALE

3 1/2" SCH. 80 PVC W/ (3) RUNS OF 750 MCM — ALUM & (1) RUN OF #1 ALUM

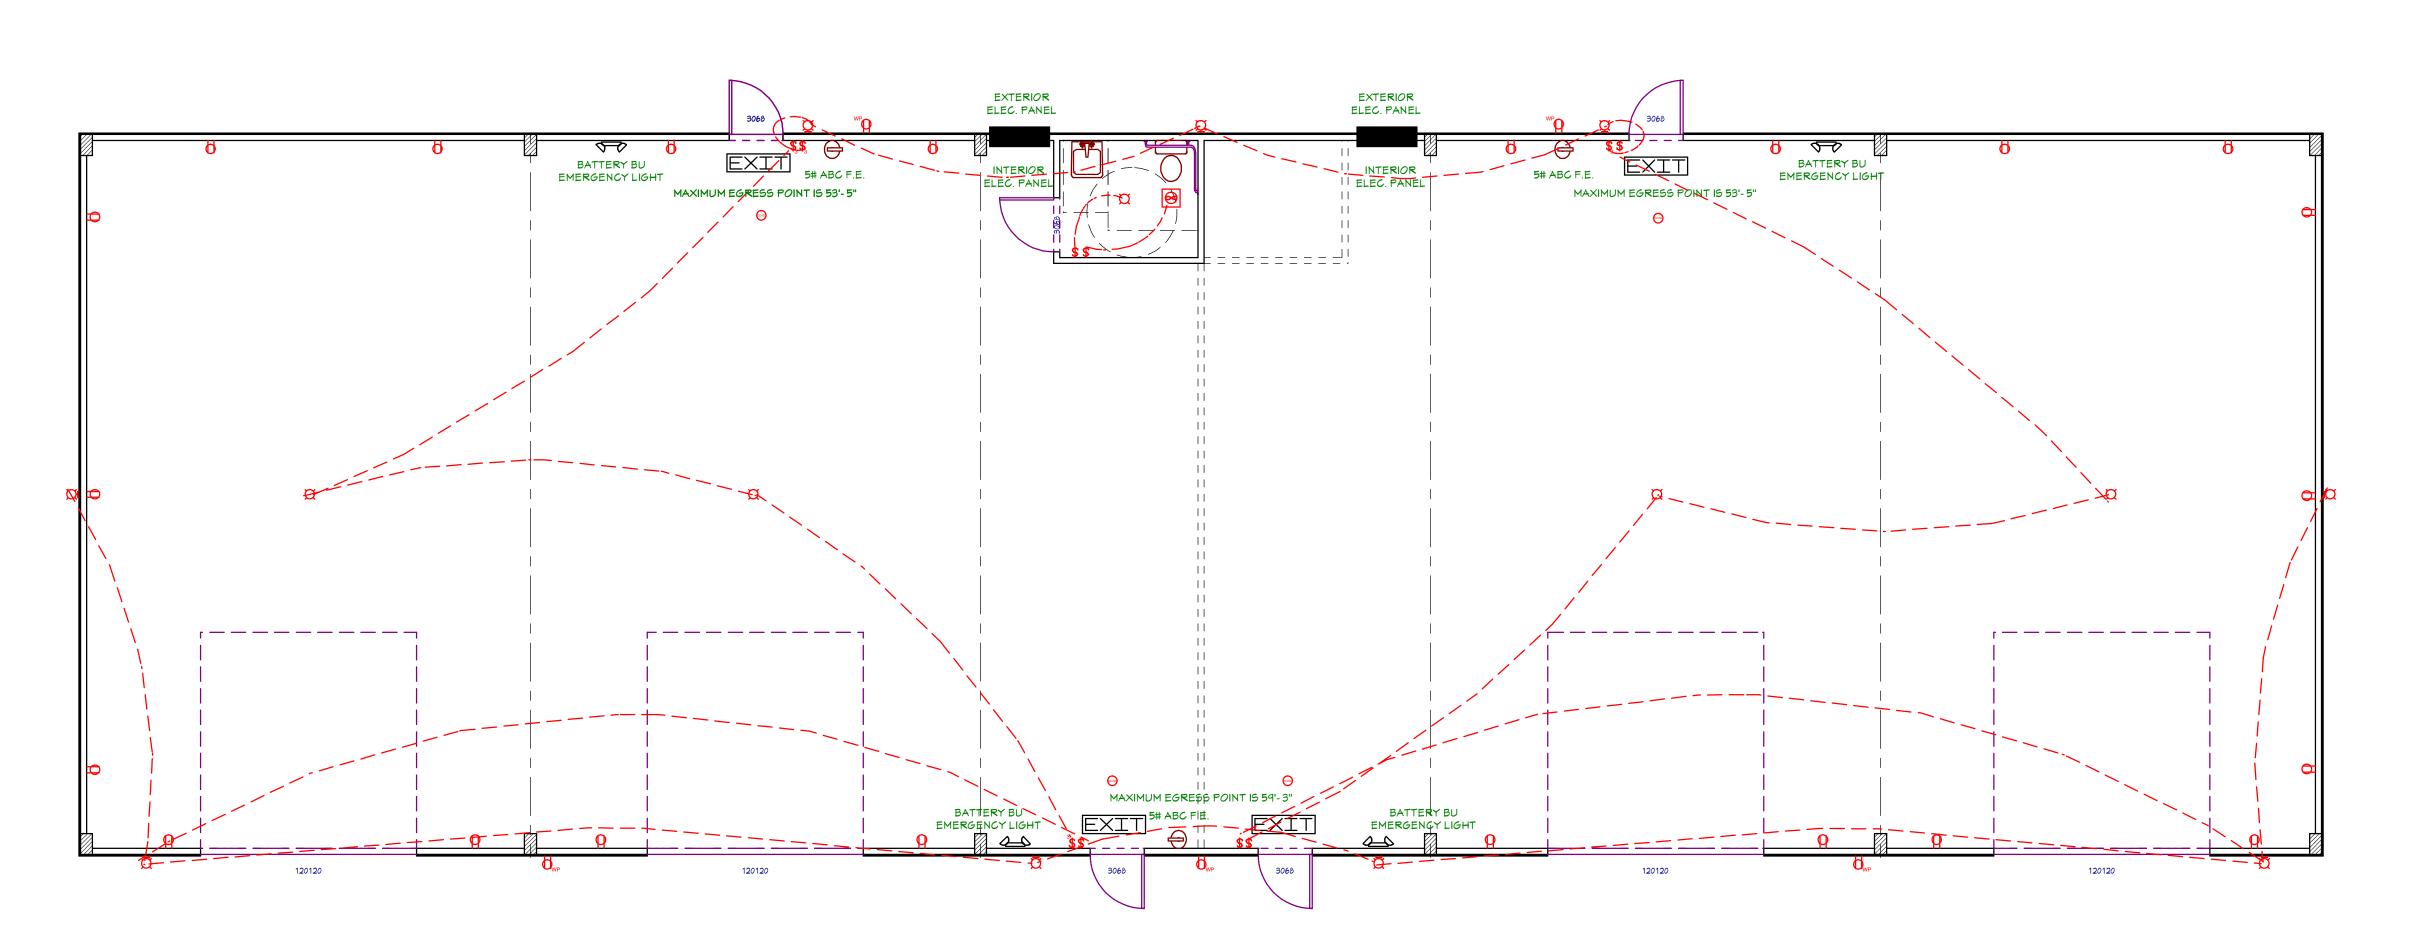

ELECTRICAL & LIFE SAFETY PLAN

SCALE 3/16" = 1'- 0"