


GENERAL NOTES:

1. G.C. TO VERIFY WITH OWNER, METHOD OF ATTACHMENT FOR ALL ITEMS ANCHORED TO, OR SUSPENDED FROM THE EXISTING STRUCTURE. LIGHT FIXTURES SHALL BE LOCATED AS INDICATED ON THE REFLECTED CEILING PLAN, THIS SHEET. REFER TO ELECTRICAL DRAWINGS FOR EXACT NUMBER AND TYPE OF LIGHT FIXTURES TO BE PROVIDED. CONTACT ARCHITECT IMMEDIATELY IF THERE ARE ANY DISCREPANCIES.
2. ELECTRICAL CONTRACTOR TO COORDINATE LIGHT FIXTURES WITH CEILING TYPES. SUBMIT SHOP DRAWINGS ON ALL FIXTURES.
3. THE G.C. SHALL SET ALL CEILINGS AND SOFFITS USING A LASER LEVEL TO ACHIEVE A CEILING THAT IS PLUMB, LEVEL, AND SQUARE TO ALL WALLS AND SOFFITS.
4. ALL NOTED CEILING DIMENSIONS ARE INDICATED AS CLEAR ABOVE FINISHED FLOOR DIMENSIONS. VERIFY THICKNESS OF FLOOR CONSTRUCTION WITH FLOORING SUB CONSTRUCTION PRIOR TO INSTALLATION OF ANY NEW CEILING CONSTRUCTION IN ORDER TO ACHIEVE REQUIRED DIMENSIONS.
5. SEE ELECTRICAL DRAWINGS FOR PLACEMENT OF LIGHT FIXTURES AND ELECTRICAL REQUIREMENTS.
6. G.C. TO PROVIDE NECESSARY BLOCKING AND BRACING FOR FIXTURE INSTALLATION AND ALL ELECTRICAL COMPONENTS TO COMPLETE THE FINAL INSTALLATION OF ALL FIXTURES. COORDINATE WITH FIXTURE MANUFACTURER.
7. THE CONTRACTOR IS RESPONSIBLE FOR THE ENTIRE INSTALLATION WHICH SHALL BE PERFORMED IN STRICT ACCORDANCE WITH ALL NATIONAL, STATE AND LOCAL CODES. THIS MAY INCLUDE ADDITIONAL ITEMS NOT INDICATED ON PLAN.
8. CONTRACTOR TO FIRM VERIFY ALL EXISTING CONDITIONS AND NOTIFY GENERAL CONTRACTOR IMMEDIATELY IF ANY DISCREPANCIES OR HIDDEN CONDITIONS OR CITY/STATE CODE COMPLIANCE CONFLICTS OCCUR. FAILURE TO NOTIFY ARCHITECT WILL RESULT IN CONTRACTOR TAKING FULL FISCAL RESPONSIBILITY FOR ANY AND ALL COSTS WHICH ARE INCURRED.

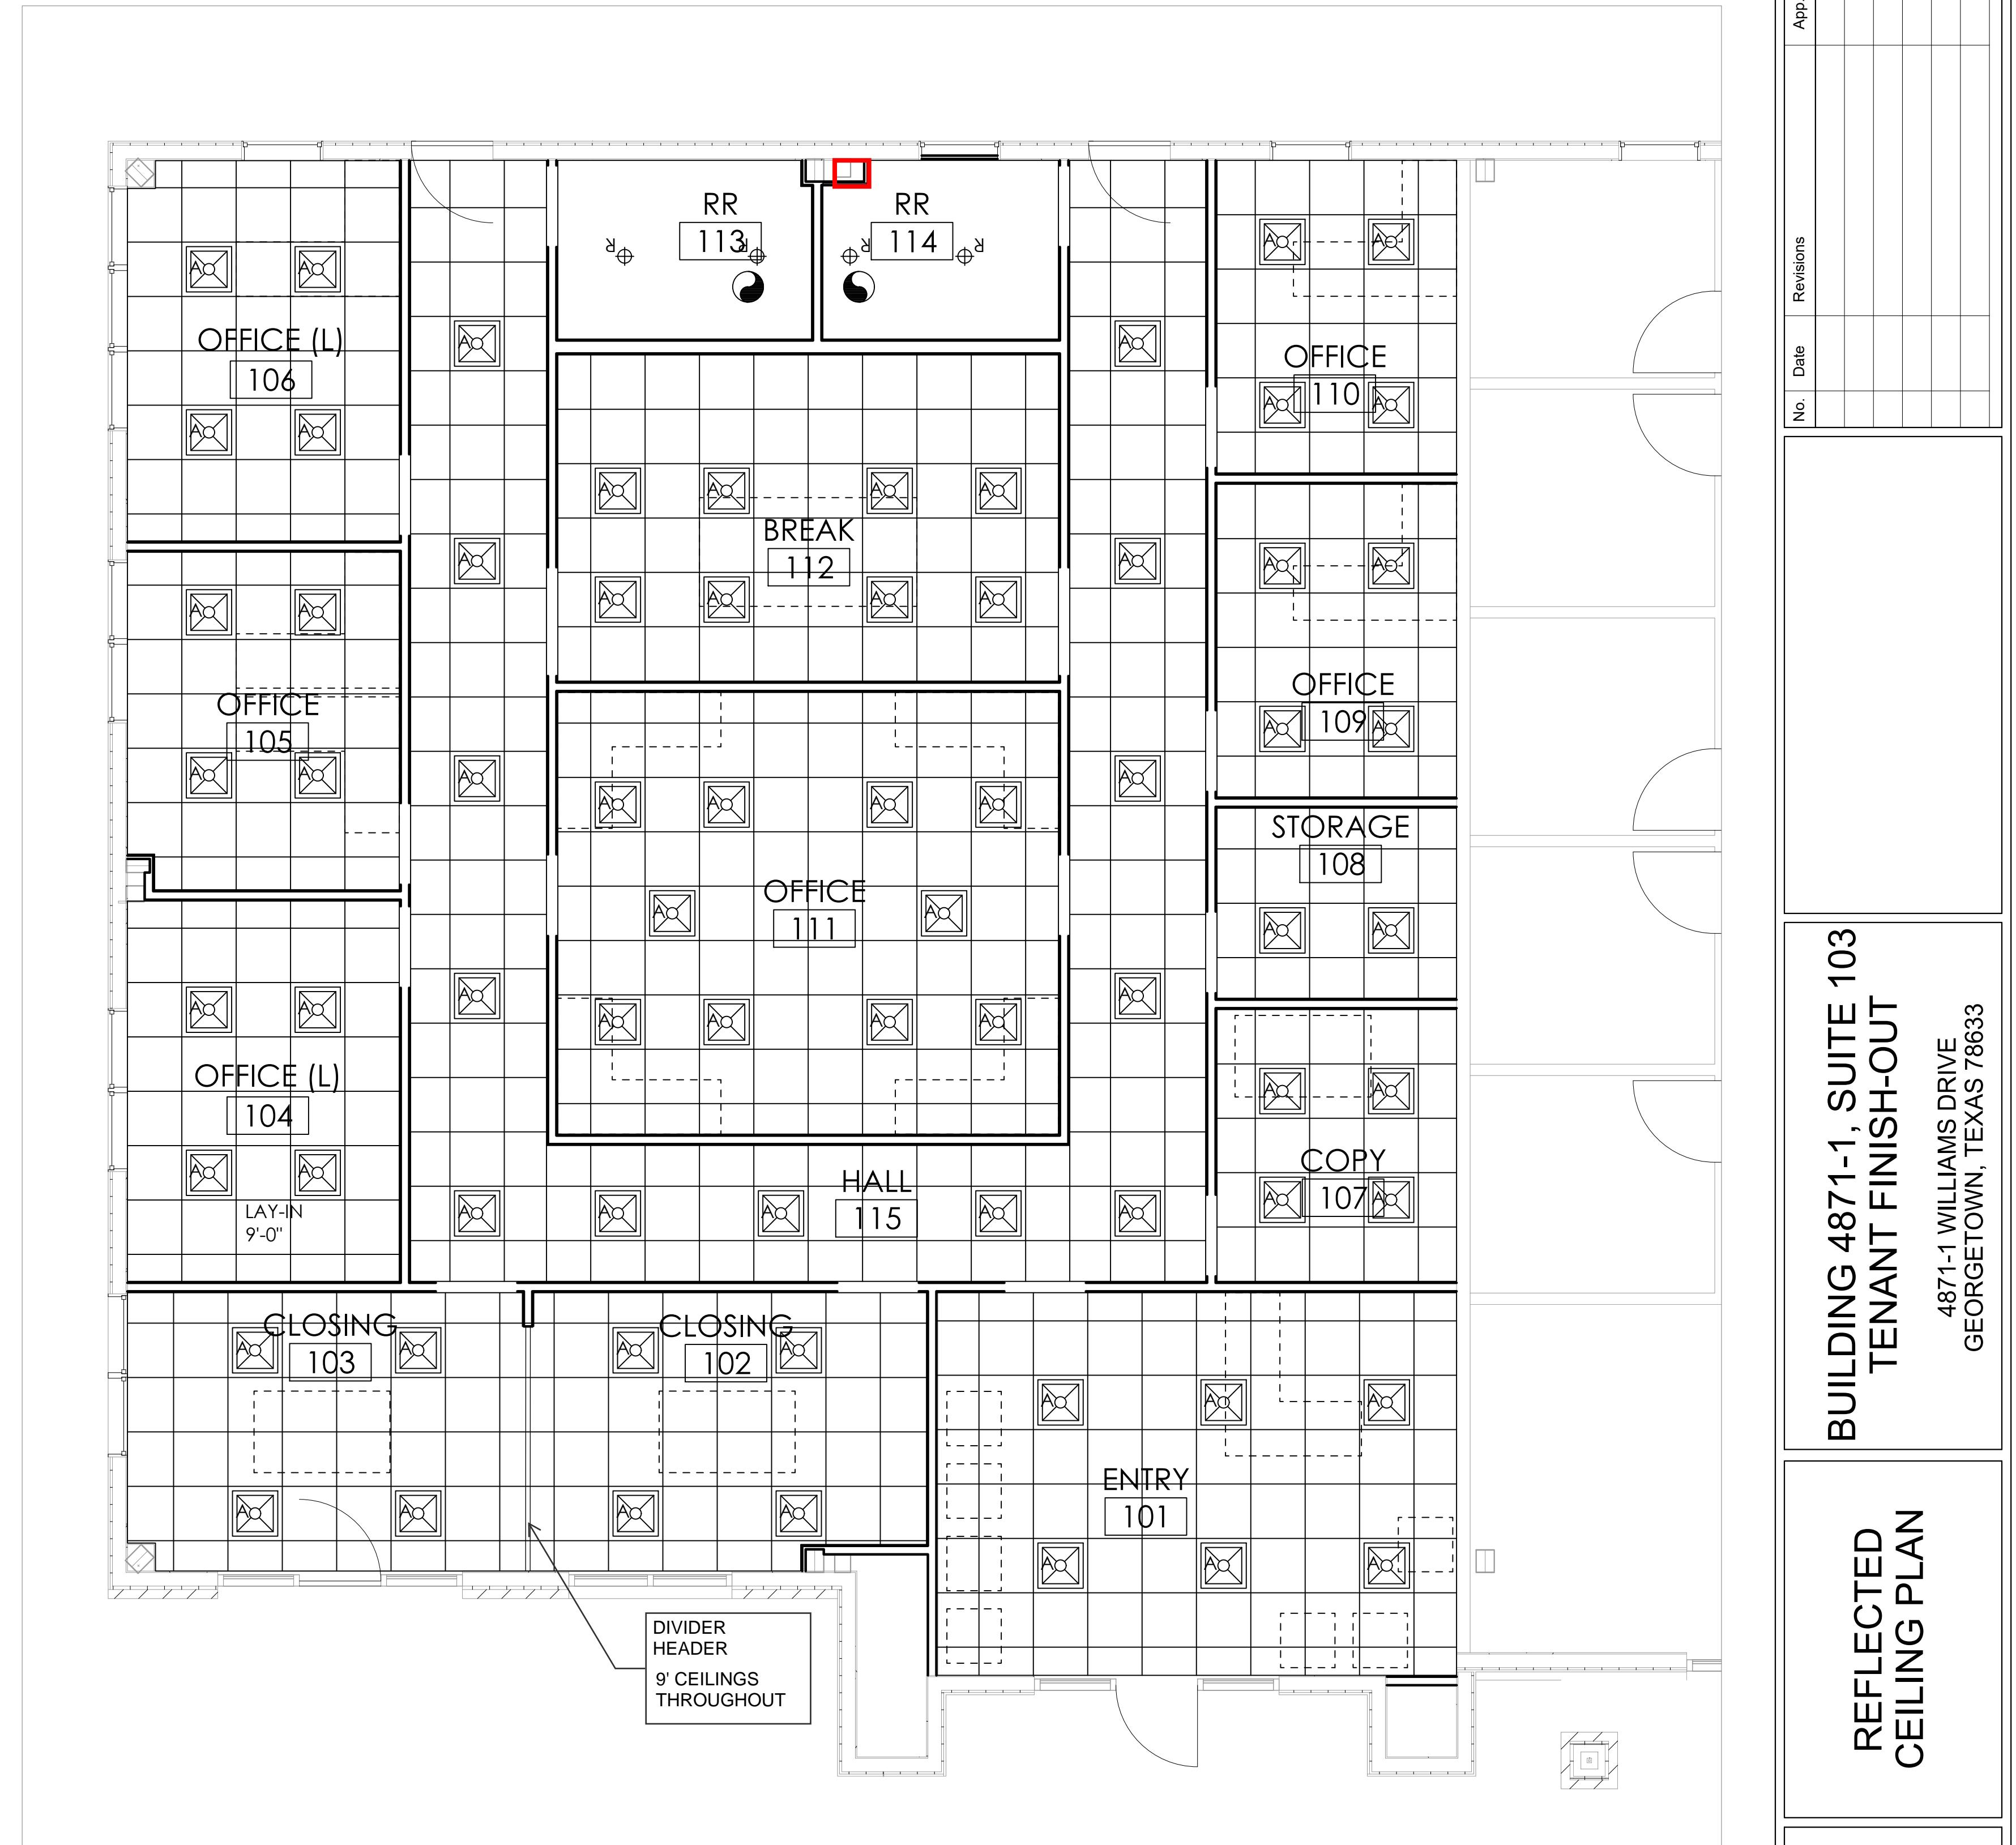

No	Date	Revisions	App.

BUILDING 4871-1, SUITE 103
TENANT FINISH-OUT
4871-1 WILLIAMS DRIVE
GEORGETOWN, TEXAS 78633

REFLECTED
CEILING PLAN

Project No.: 200715
Issued: 06/01/2021
Drawn By: DJB
Checked By: JAB

A.03